


ELECTRICAL POWER NOTES:

1. ALL WORK IS NEW UNLESS OTHERWISE NOTED.
2. REFER TO ARCHITECTURAL PLANS FOR EXACT DIMENSIONS AND LOCATIONS. VERIFY WITH ARCHITECTURAL PLANS AND COORDINATE WITH THE GENERAL CONTRACTOR PRIOR TO ROUGH-IN. NOTIFY THE ARCHITECT/G.C. OF ANY DISCREPANCIES IF DISCREPANCIES ARE NOTED. DO NOT PROCEED WITHOUT ARCHITECTURAL APPROVAL.
3. PROVIDE PULL STRING IN CONDUITS FOR FUTURE LIGHTING AND OTHER CIRCUIT.
4. CONDUIT SHALL BE INSTALLED 24" BELOW GRADE.
5. ALL LAWN BOXES SHALL BE LOCATED IN LAWN AREAS; VERIFY EXACT LOCATIONS IN FIELD.

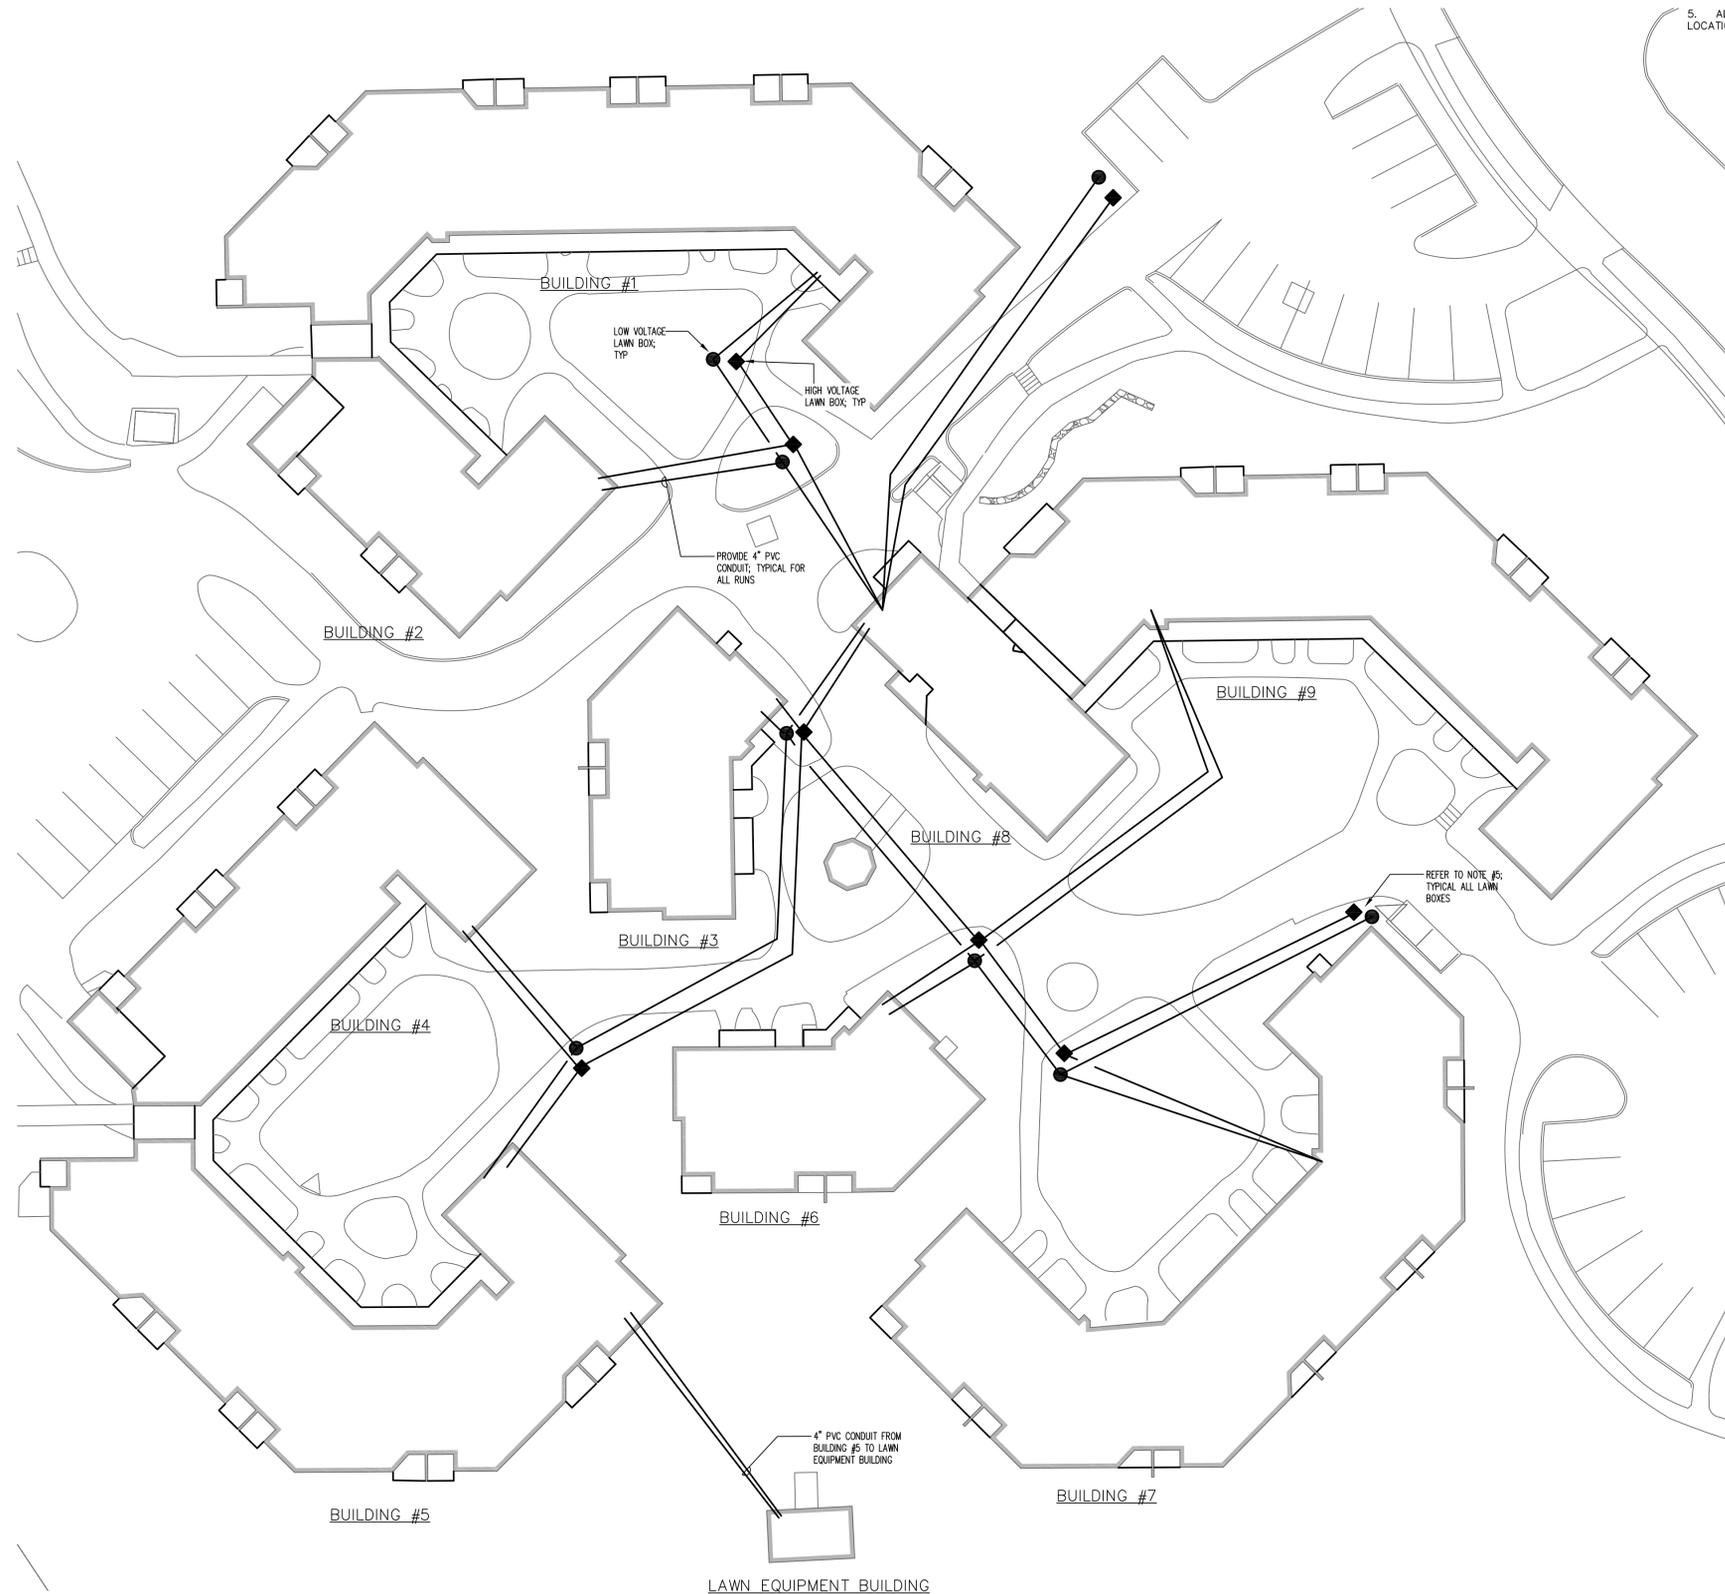

FIRST FLOOR LEVEL - SITE ELECTRICAL PLAN
SCALE: 1" = 20'-0"



THIS DOCUMENT, THE IDEAS AND DESIGNS INCORPORATED HEREIN, AS AN ENGINEER'S DESIGN, IS THE PROPERTY OF THE DESIGNER AND IS NOT TO BE USED, IN WHOLE OR IN PART, FOR ANY OTHER PROJECT OR BY ANY OTHER PERSON, OR CORPORATION, WITHOUT THE WRITTEN AUTHORIZATION OF THE DESIGNER. ANY SUCH UNAUTHORIZED USE WILL BE CONSIDERED A VIOLATION OF PROFESSIONAL ETHICS AND THE DESIGNER WILL BEAR NO RESPONSIBILITY ARISING OUT OF SUCH USE.

SHEET TITLE	FIRST FLOOR LEVEL - SITE CONDUIT PLAN
JOB NAME	PARISH COURT FIRE ALARM/CALL-FOR-AID UPGRADE
SCALE	as noted
JOB NO.	13041
DRAWN	KAL/RS
CHECKED	SE-3
DATE	02/28/13
FAIRFIELD, CT	