

SLAM



REGIONAL SCHOOL DISTRICT NO. 14

Nonnewaug High School Renovations

5 Minortown Rd
Woodbury, CT 06798

PHASE 3 OF 3 FIXTURES, FURNISHINGS AND EQUIPMENT

State Project #214-0093 RN
State Project #214-0096 BE/A/CV

Owner:
Regional School District No. 14
5 Minortown Road
Woodbury, CT 06798

Communications / Security / Technology:
Guillen Technology Consultants
9 Moody Road, Building D, Suite 18
Enfield, CT 06082

Owner Representative:
Colliers International
135 New Road
Madison, CT 06443

Architect / Landscape Architect /
Structural Engineer:
The S/L/A/M Collaborative
80 Glastonbury Boulevard
Glastonbury, CT 06033

Civil Engineer / Land Surveyor:
BSC Group
300 Winding Brook Drive
Glastonbury, CT 06033

Mechanical / Electrical / Plumbing / Fire Protection:
Consulting Engineering Services, Inc.
811 Middle Street
Middletown, CT 06457

DRAWING LIST:

COVER SHEET

REFERENCE (Phase 2 of 3 Drawings for Coordination Only)

GC00 CODE INFORMATION
GC100 LOWER LEVEL FLOOR FIRE SAFETY PLAN
GC101 FIRST FLOOR FIRE SAFETY PLAN
GC102 SECOND FLOOR FIRE SAFETY PLAN
GC103 ATTIC FLOOR FIRE SAFETY PLAN
L201A SITE LAYOUT - PART A

A100 OVERALL LOWER LEVEL PLAN
A101 OVERALL FIRST FLOOR PLAN
A102 OVERALL ROOF PLAN

FURNITURE

I100C LOWER LEVEL FURNITURE PLAN - PART C
I100E LOWER LEVEL FURNITURE PLAN - PART E
I101A FIRST FLOOR FURNITURE PLAN - PART A
I101B FIRST FLOOR FURNITURE PLAN - PART B
I101C FIRST FLOOR FURNITURE PLAN - PART C
I101D FIRST FLOOR FURNITURE PLAN - PART D
I101E FIRST FLOOR FURNITURE PLAN - PART E
I102A SECOND FLOOR FURNITURE PLAN - PART A
I102B SECOND FLOOR FURNITURE PLAN - PART B
I102C SECOND FLOOR FURNITURE PLAN - PART C
I102D SECOND FLOOR FURNITURE PLAN - PART D
I200 FURNITURE SCHEDULE BY ROOM
I201 FURNITURE SCHEDULE BY ROOM - ORGANIZED BY SHEET



Site Location Map

Binding: VOLUME 1 OF 1
Issued for: CONSTRUCTION DOCUMENTS
Date: 01/12/2018
Proj No. : 15232.00

CODE INFORMATION BUILDING #1 (1970 ACADEMIC BUILDING)

1. OCCUPANCY CLASSIFICATION (CBC 302): USE GROUP(S) A.1, A.3, A.4, E, S-2... 2. CONSTRUCTION TYPE CLASSIFICATION (CBC 602.0): MINIMUM TYPE OF CONSTRUCTION REQUIRED: IIB... 3. BUILDING HEIGHT (CBC 503.1 & 504.1): ALLOWABLE HEIGHT IN STORIES/FEET: 3 ST/ 75'... 4. ACTUAL BUILDING AREA (CBC 502.1): GROSS BUILDING AREA PER FLOOR: LOWER LEVEL GROSS BUILDING AREA: 16,018 SF...

5. AREA MODIFICATIONS TO TABLE 503 (CBC 506.1): TOTAL PERIMETER: 235 FT / 517 FT... 6. CASE 1 - SINGLE OCCUPANCY (CBC 506.1) OR NON-SEPARATED MIXED USES (CBC 508.3): ALLOWABLE AREA: A) ADJUSTED BUILDING AREA: 56,285 SF / 3.62 = 15,548 SF...

7. CASE 2 - SEPARATED MIXED USES (CBC 508.4): ALLOWABLE AREA (CBC 508.4.2): NOT APPLICABLE... 8. FIRE RESISTANCE RATED REQUIREMENTS FOR BUILDING ELEMENTS (CBC TABLE 601): BUILDING ELEMENT STRUCTURAL FRAME, INCLUDING COLUMNS, GIRDERS, TRUSSES... RATING NR NR...

Table with 3 columns: BUILDING ELEMENT, FIRE RESISTANCE (RECD), RATING (PROVIDED). Rows include structural frame, bearing walls, exterior walls, floor construction, roof construction, shafts, corridors, and tenant separation.

NR = NO RATING
N/A = NOT APPLICABLE. CONDITION NOT PRESENT IN DESIGN
1 HR = 1 HOUR RATING
2 HR = 2 HOUR RATING
3 HR = 3 HOUR RATING
0 HR = UNRATED SMOKE PARTITION

BUILDING #2 (2001 MUSIC ADDITION)

1. OCCUPANCY CLASSIFICATION (CBC 302): USE GROUP(S) E... 2. CONSTRUCTION TYPE CLASSIFICATION (CBC 602.0): MINIMUM TYPE OF CONSTRUCTION REQUIRED: IIB... 3. BUILDING HEIGHT (CBC 503.1 & 504.1): ALLOWABLE HEIGHT IN STORIES/FEET: 3 ST/ 75'... 4. ACTUAL BUILDING AREA (CBC 502.1): GROSS BUILDING AREA PER FLOOR: FIRST FLOOR GROSS BUILDING AREA: 3,381 SF...

5. AREA MODIFICATIONS TO TABLE 503 (CBC 506.1): TOTAL PERIMETER: 60 FT / 87 FT... 6. CASE 1 - SINGLE OCCUPANCY (CBC 506.1) OR NON-SEPARATED MIXED USES (CBC 508.3): ALLOWABLE AREA: A) ADJUSTED BUILDING AREA: 3,381 SF / 4.36 = 775 SF...

7. CASE 2 - SEPARATED MIXED USES (CBC 508.4): ALLOWABLE AREA (CBC 508.4.2): NOT APPLICABLE... 8. FIRE RESISTANCE RATED REQUIREMENTS FOR BUILDING ELEMENTS (CBC TABLE 601): BUILDING ELEMENT STRUCTURAL FRAME, INCLUDING COLUMNS, GIRDERS, TRUSSES... RATING NR NR...

Table with 3 columns: BUILDING ELEMENT, FIRE RESISTANCE (RECD), RATING (PROVIDED). Rows include structural frame, bearing walls, exterior walls, floor construction, roof construction, shafts, corridors, and tenant separation.

NR = NO RATING
N/A = NOT APPLICABLE. CONDITION NOT PRESENT IN DESIGN
1 HR = 1 HOUR RATING
2 HR = 2 HOUR RATING
3 HR = 3 HOUR RATING
0 HR = UNRATED SMOKE PARTITION

BUILDING #3 (2001 STUDENT SERVICES BUILDING)

1. OCCUPANCY CLASSIFICATION (CBC 302): USE GROUP(S) A-2, A-3, B, E... 2. CONSTRUCTION TYPE CLASSIFICATION (CBC 602.0): MINIMUM TYPE OF CONSTRUCTION REQUIRED: IIB... 3. BUILDING HEIGHT (CBC 503.1 & 504.1): ALLOWABLE HEIGHT IN STORIES/FEET: 3 ST/ 75'... 4. ACTUAL BUILDING AREA (CBC 502.1): GROSS BUILDING AREA PER FLOOR: LOWER LEVEL GROSS BUILDING AREA: 17,260 SF...

5. AREA MODIFICATIONS TO TABLE 503 (CBC 506.1): TOTAL PERIMETER: 134 FT / 272 FT... 6. CASE 1 - SINGLE OCCUPANCY (CBC 506.1) OR NON-SEPARATED MIXED USES (CBC 508.3): ALLOWABLE AREA: A) ADJUSTED BUILDING AREA: 20,049 SF / 3.61 = 5,554 SF...

7. CASE 2 - SEPARATED MIXED USES (CBC 508.4): ALLOWABLE AREA (CBC 508.4.2): NOT APPLICABLE... 8. FIRE RESISTANCE RATED REQUIREMENTS FOR BUILDING ELEMENTS (CBC TABLE 601): BUILDING ELEMENT STRUCTURAL FRAME, INCLUDING COLUMNS, GIRDERS, TRUSSES... RATING NR NR...

Table with 3 columns: BUILDING ELEMENT, FIRE RESISTANCE (RECD), RATING (PROVIDED). Rows include structural frame, bearing walls, exterior walls, floor construction, roof construction, shafts, corridors, and tenant separation.

NR = NO RATING
N/A = NOT APPLICABLE. CONDITION NOT PRESENT IN DESIGN
1 HR = 1 HOUR RATING
2 HR = 2 HOUR RATING
3 HR = 3 HOUR RATING
0 HR = UNRATED SMOKE PARTITION

9. OCCUPANCY LOAD - REFER TO FIRESAFETY PLANS FOR OCCUPANT LOADS OF INDIVIDUAL ROOMS (CBC 1004.1)

DESIGN TOTAL FOR EACH FLOOR: LOWER LEVEL: 614 OCC... 10. MODIFICATIONS: APPROVED: A) CODE SECTION: 2902.1 NUMBER: M-754-17... 11. ACCESSIBLE BUILDING: DESIGNATED: X NON-DESIGNATED: ... 12. MINIMUM PLUMBING FIXTURE COUNT (CBC TABLE 2902.1): GROUP A-1 OCCUPANCY DESIGN LOAD: 616 WIC MALE: 2.46 WIC FEMALE: 4.74...

Table showing plumbing fixture counts for various occupancy groups (A-1, A-2, A-3, A-4, B, S-2) with columns for WIC MALE, WIC FEMALE, and REQUIRED fixtures.

Table showing total building plumbing fixture counts with columns for WIC MALE, WIC FEMALE, and PROVIDED fixtures.

13. ENTIRE BUILDING SPRINKLERED (CBC 903.1): YES... 14. THRESHOLD BUILDING CONDITIONS (CBC 107.7): NO... 15. CODES TO WHICH THIS PROJECT WAS DESIGNED: 2016 STATE OF CONNECTICUT BUILDING CODE - CSBC...

16. BUILDING AREAS FOR GRANT CALCULATION (ENTIRE FACILITY): EXISTING CENTRAL OFFICE CONSTRUCTION PRIOR TO THIS PROJECT: 5,328 SF... 17. EXIT ACCESS: COMMON PATH OF TRAVEL LIMITATIONS (CBC 1014.3): GROUP A ALLOWABLE: 75' (A OCC) PROVIDED: SEE PLANS... 18. EGRESS CAPACITY OF DOORS (CBC 1005.3.2): DOORS WITH STANDARD HOLLOW METAL FRAMES AND BUTT HINGES... 19. INTERIOR FINISHES (CBC 803.9): GROUP A OCCUPANCY: VERTICAL EXITS & EXIT PASSAGEWAYS - CLASS A OR B... 20. HISTORIC BUILDING: NO... 21. EGRESS-RELATED CODE INFORMATION: FLOOR AREA ALLOWANCES PER OCCUPANT (CBC 1004.1.2): CLASSROOM OCCUPANCY - 20 NET...

22. THERMAL ENVELOPE: SEE DRAWING A500

16. BUILDING AREAS FOR GRANT CALCULATION (ENTIRE FACILITY): EXISTING CENTRAL OFFICE CONSTRUCTION PRIOR TO THIS PROJECT: 5,328 SF... 17. EXIT ACCESS: COMMON PATH OF TRAVEL LIMITATIONS (CBC 1014.3): GROUP A ALLOWABLE: 75' (A OCC) PROVIDED: SEE PLANS... 18. EGRESS CAPACITY OF DOORS (CBC 1005.3.2): DOORS WITH STANDARD HOLLOW METAL FRAMES AND BUTT HINGES... 19. INTERIOR FINISHES (CBC 803.9): GROUP A OCCUPANCY: VERTICAL EXITS & EXIT PASSAGEWAYS - CLASS A OR B... 20. HISTORIC BUILDING: NO... 21. EGRESS-RELATED CODE INFORMATION: FLOOR AREA ALLOWANCES PER OCCUPANT (CBC 1004.1.2): CLASSROOM OCCUPANCY - 20 NET...

22. THERMAL ENVELOPE: SEE DRAWING A500

Table showing egress capacity of doors with columns for SIZE, CLEAR WIDTH, MAX. OCC. LOAD (CAP = 2700C), and OCCUPANTS.

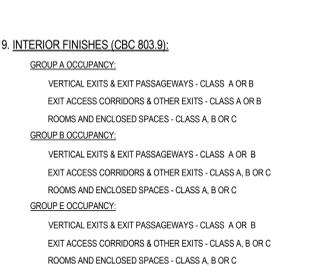


Table with 3 columns: Number, Date, Issued For. Shows a list of drawing revisions.

22. THERMAL ENVELOPE: SEE DRAWING A500

SLAM The S/L/A/M Collaborative

80 Glastonbury Blvd Glastonbury, CT 06033-4410 phone 860 657.8077 fax 860 657.3141

www.slamcoll.com

Drawn KH Checked


TOTAL BUILDING AREA (TOTAL NEW CONSTRUCTION FOR THIS PROJECT MINUS OPEN AREAS): CENTRAL OFFICE: 5,181 SF HIGH SCHOOL: 136,875 SF TOTAL PROJECT: 142,057 SF

TOTAL CONSTRUCTED BUILDING AREA (TO EXTERIOR FACE OF EXTERIOR WALLS, AKA "CONTRACTOR BUILDING AREA"): 151,949 SF

Region 14 Schools Inspiring Excellence

NONNEWAUG HIGH SCHOOL PHASE 2 of 3 SITE AND BUILDING CONSTRUCTION/RENOVATION 5 MINORTOWN RD WOODBURY, CT 06798

STATE PROJECT NO. 214-0093 RN STATE PROJECT NO. 214-0096 BE/A/CV

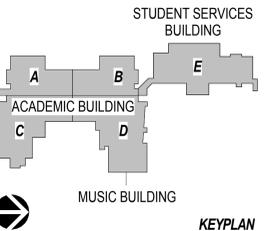

KEYPLAN

Table with 3 columns: Number, Date, Issued For. Shows a list of drawing revisions.

CODE INFORMATION

Date: 7/17/2017 Scale: 12" = 1'-0" Proj. Number: 15232.00 Drawing Number: GC00

FOR REFERENCE ONLY

Drawn KH, PH, CF	
Checked	




NONNEWAUG HIGH SCHOOL

PHASE 2 of 3
 SITE AND BUILDING
 CONSTRUCTION/RENOVATION

5 MINORTOWN RD
 WOODBURY, CT 06798

STATE PROJECT NO. 214-0093 RN
 STATE PROJECT NO. 214-0096 BE/A/CV

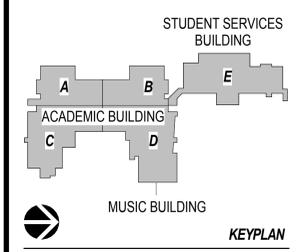

Number	Date	Issued For
	11/15/2017	ISSUED FOR BID

LOWER LEVEL FLOOR FIRE SAFETY PLAN

Date 7/17/2017	Drawing Number GC100
Scale As indicated	
Proj. Number 15232.00	

1 0.0 - LOWER LEVEL FIRE SAFETY PLAN
 1" = 20'-0"

FOR REFERENCE ONLY

FIRE SAFETY LEGEND
 REFER TO FLOOR PLANS AND WALL PARTITION TYPES (DRAWING A601) FOR SPECIFIC PARTITION DETAILS AND LOCATIONS

ROOM OCCUPANT LOAD
 AREA IN SQ. FT.
 800 SF = 60
 100 SF = 10


EXIT CAPACITY
 ACTUAL LOAD
 EXIT CAPACITY

DIRECTION OF TRAVEL WITH ACCUMULATED OCCUPANT LOAD
 MAXIMUM TRAVEL DISTANCE FROM FURTHEST POINT

NON ACCESSIBLE EXIT
ACCESSIBLE EXIT

FIRE RATING DESIGNATIONS:
 NON-FIRE RATED SMOKE PARTITION (IBC 710)
 1 HOUR RATED WALL
 2 HOUR RATED WALL

GROSS OCCUPANCY AREA FOR BUSINESS USE
OCCUPANCY AREA FOR ASSEMBLY USE

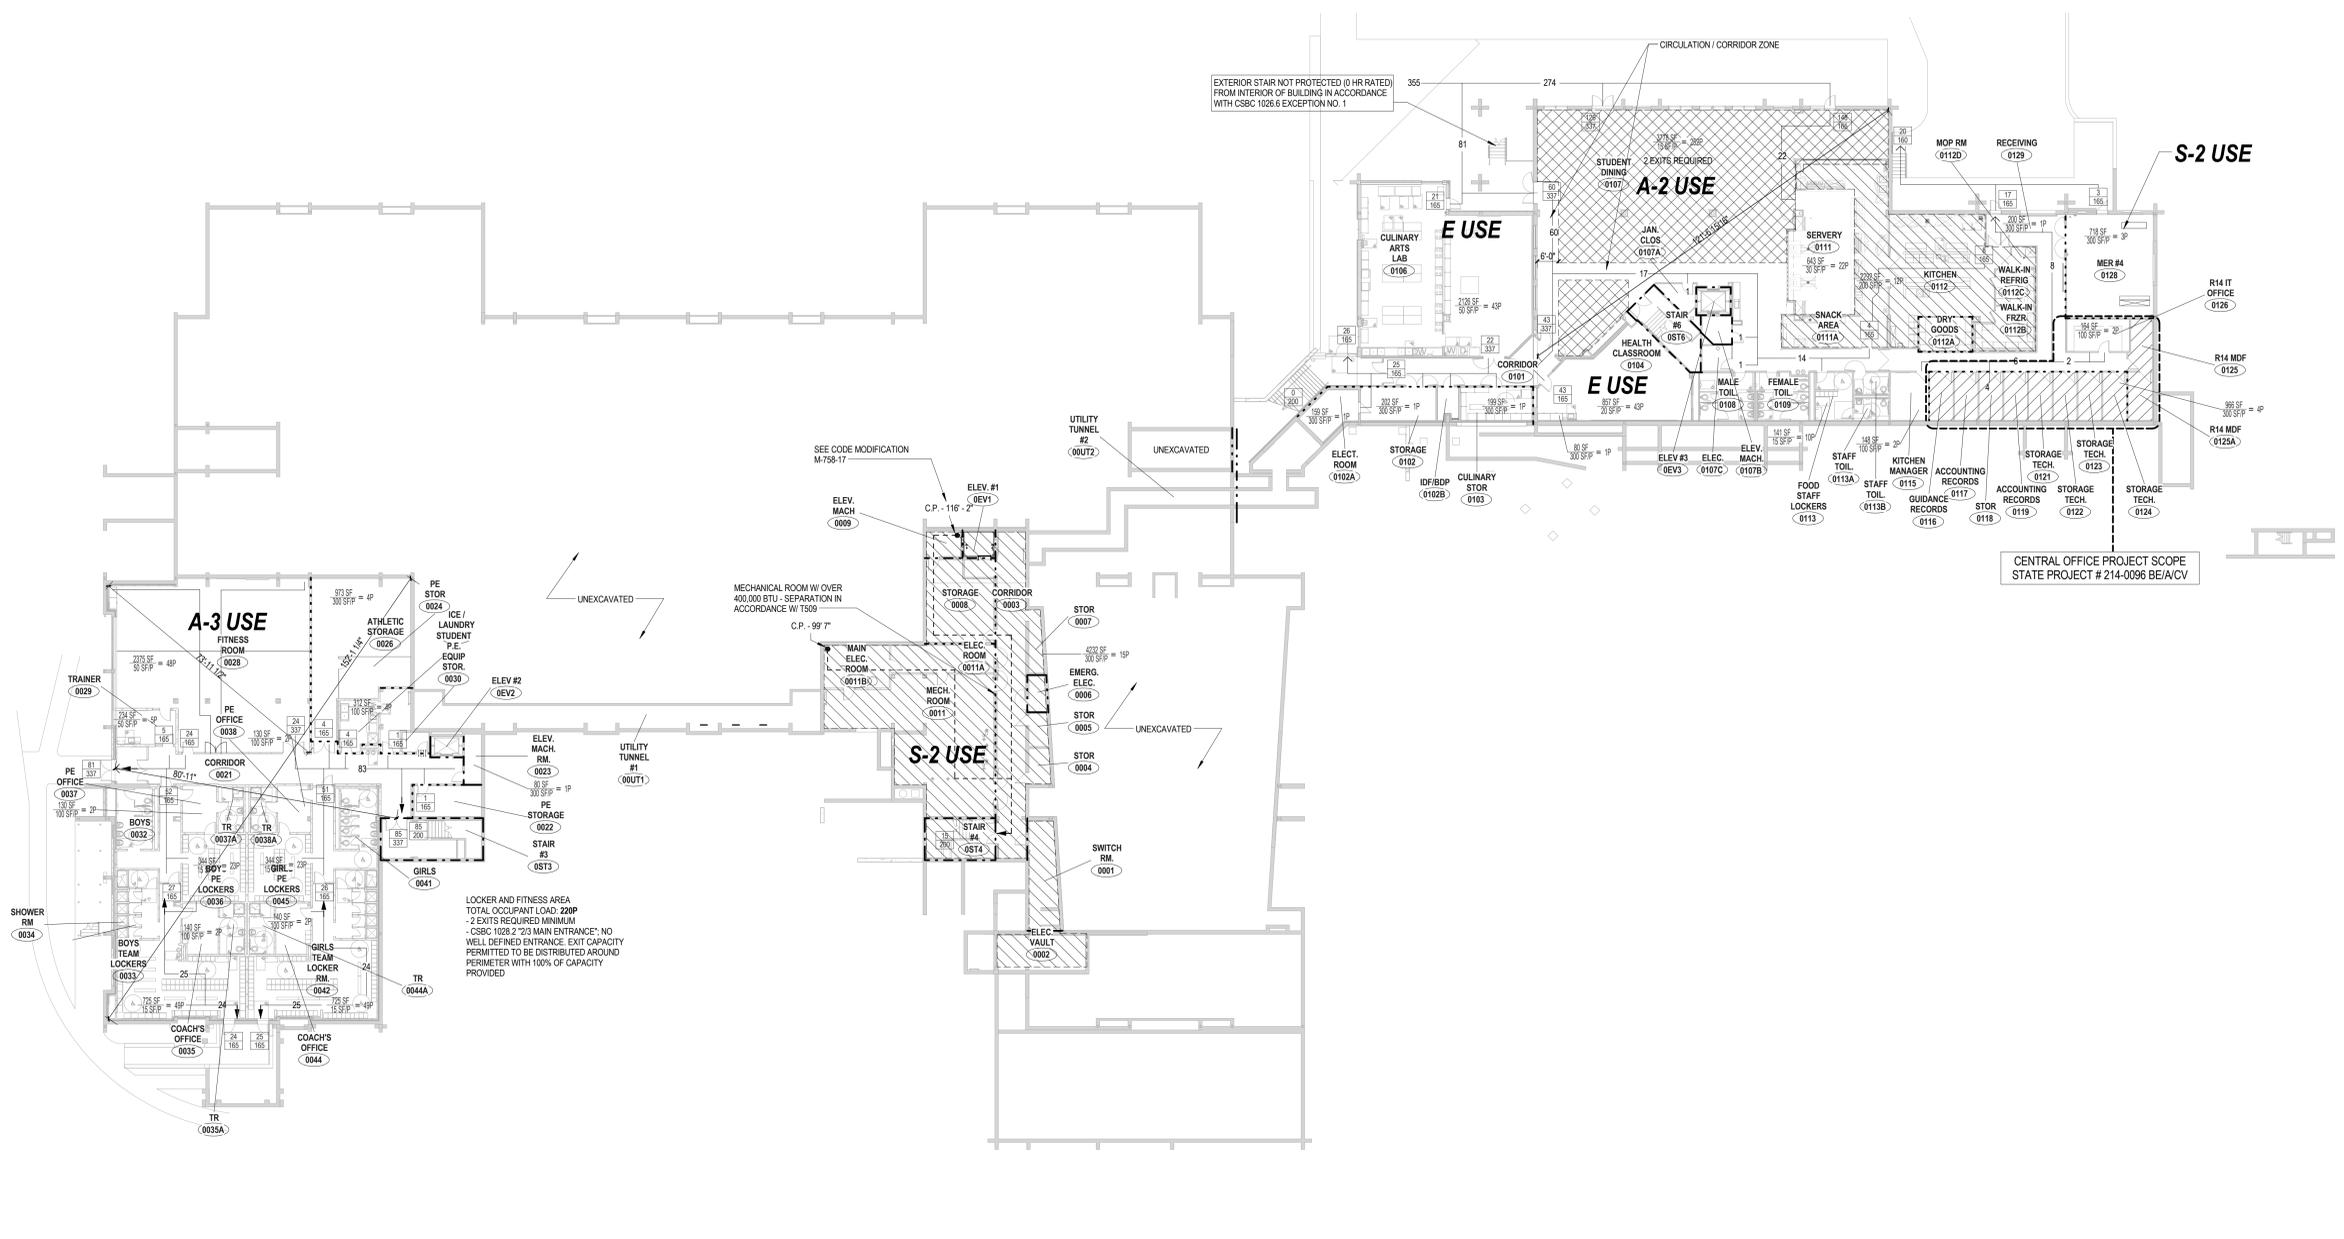

Drawn
KH, CF, PH
Checked




NONNEWAUG HIGH SCHOOL

PHASE 2 of 3
SITE AND BUILDING
CONSTRUCTION/RENOVATION

5 MINORTOWN RD
WOODBURY, CT 06798

STATE PROJECT NO. 214-0093 RN
STATE PROJECT NO. 214-0096 BE/A/CV

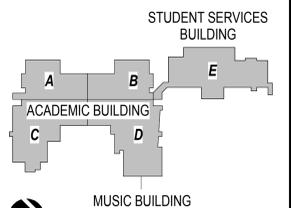


KEYPLAN

Number	Date	Issued For
11/15/2017		ISSUED FOR BID

FIRST FLOOR FIRE SAFETY PLAN

Date: 7/17/2017
Scale: As indicated
Proj. Number: 15232.00
Drawing Number: **GC101**

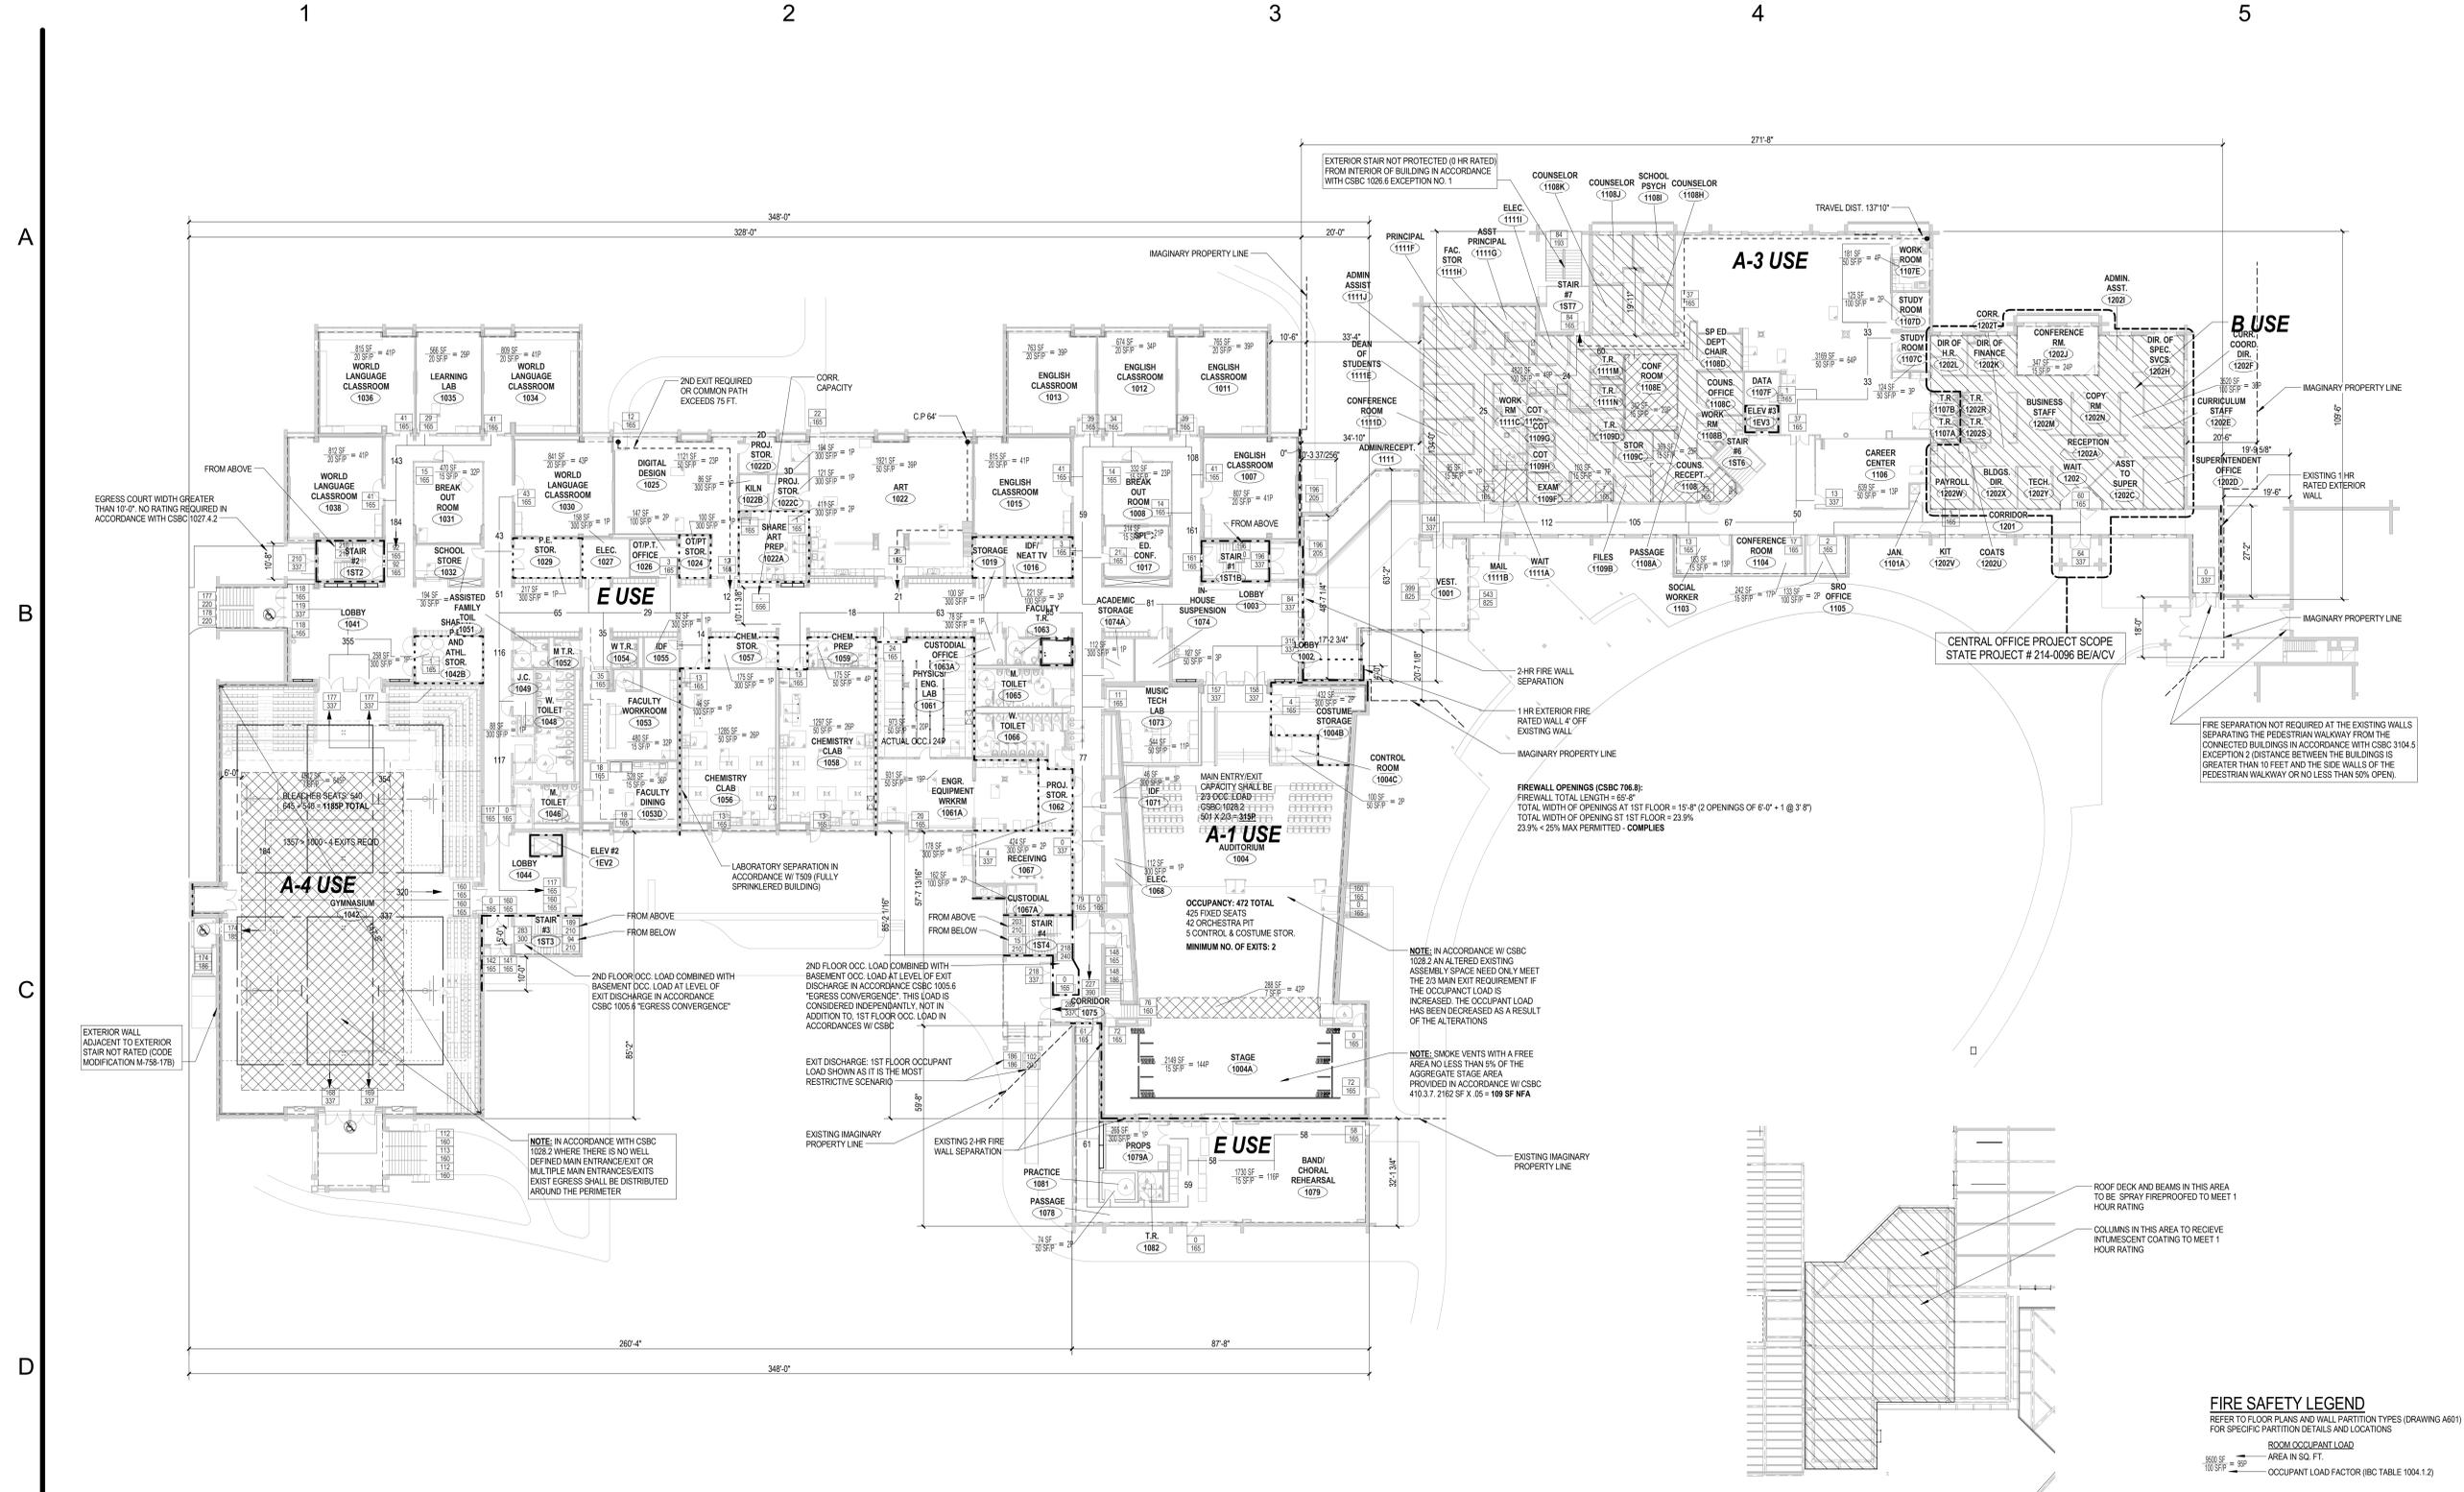

1E 1.0 - FIRST FLOOR FIRE SAFETY PLAN
1" = 20'-0"

4E FIREPROOF DIAGRAM
1/16" = 1'-0"

FOR REFERENCE ONLY

FIRE SAFETY LEGEND

REFER TO FLOOR PLANS AND WALL PARTITION TYPES (DRAWING 601) FOR SPECIFIC PARTITION DETAILS AND LOCATIONS

- ROOM OCCUPANT LOAD
- AREA IN SQ. FT.
- OCCUPANT LOAD FACTOR (IBC TABLE 1004.1.2)
- EXIT CAPACITY
- ACTUAL LOAD
- EXIT CAPACITY
- DIRECTION OF TRAVEL WITH ACCUMULATED OCCUPANT LOAD
- MAXIMUM TRAVEL DISTANCE FROM FURTHEST POINT
- NON ACCESSIBLE EXIT
- ACCESSIBLE EXIT

FIRE RATING DESIGNATIONS:

- NON-FIRE RATED SMOKE PARTITION (IBC 710)
- 1 HOUR RATED WALL
- 2 HOUR RATED WALL
- GROSS OCCUPANCY AREA FOR BUSINESS USE
- OCCUPANCY AREA FOR ASSEMBLY USE

C:\Revit\Projects\Nonnewaug_A_SIAM_22016_CF\Drawn.rvt


Drawn
KH, CF
Checked



NONNEWAUG HIGH SCHOOL

PHASE 2 of 3
SITE AND BUILDING
CONSTRUCTION/RENOVATION
5 MINORTOWN RD
WOODBURY, CT 06798

STATE PROJECT NO. 214-0093 RN
STATE PROJECT NO. 214-0096 BE/A/CV

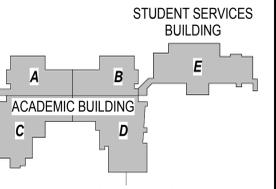


KEYPLAN

Number	Date	Issued For
11/15/2017		ISSUED FOR BID

SECOND FLOOR FIRE SAFETY PLAN

Date: 7/17/2017
Scale: As indicated
Proj. Number: 15232.00
Drawing Number: GC102

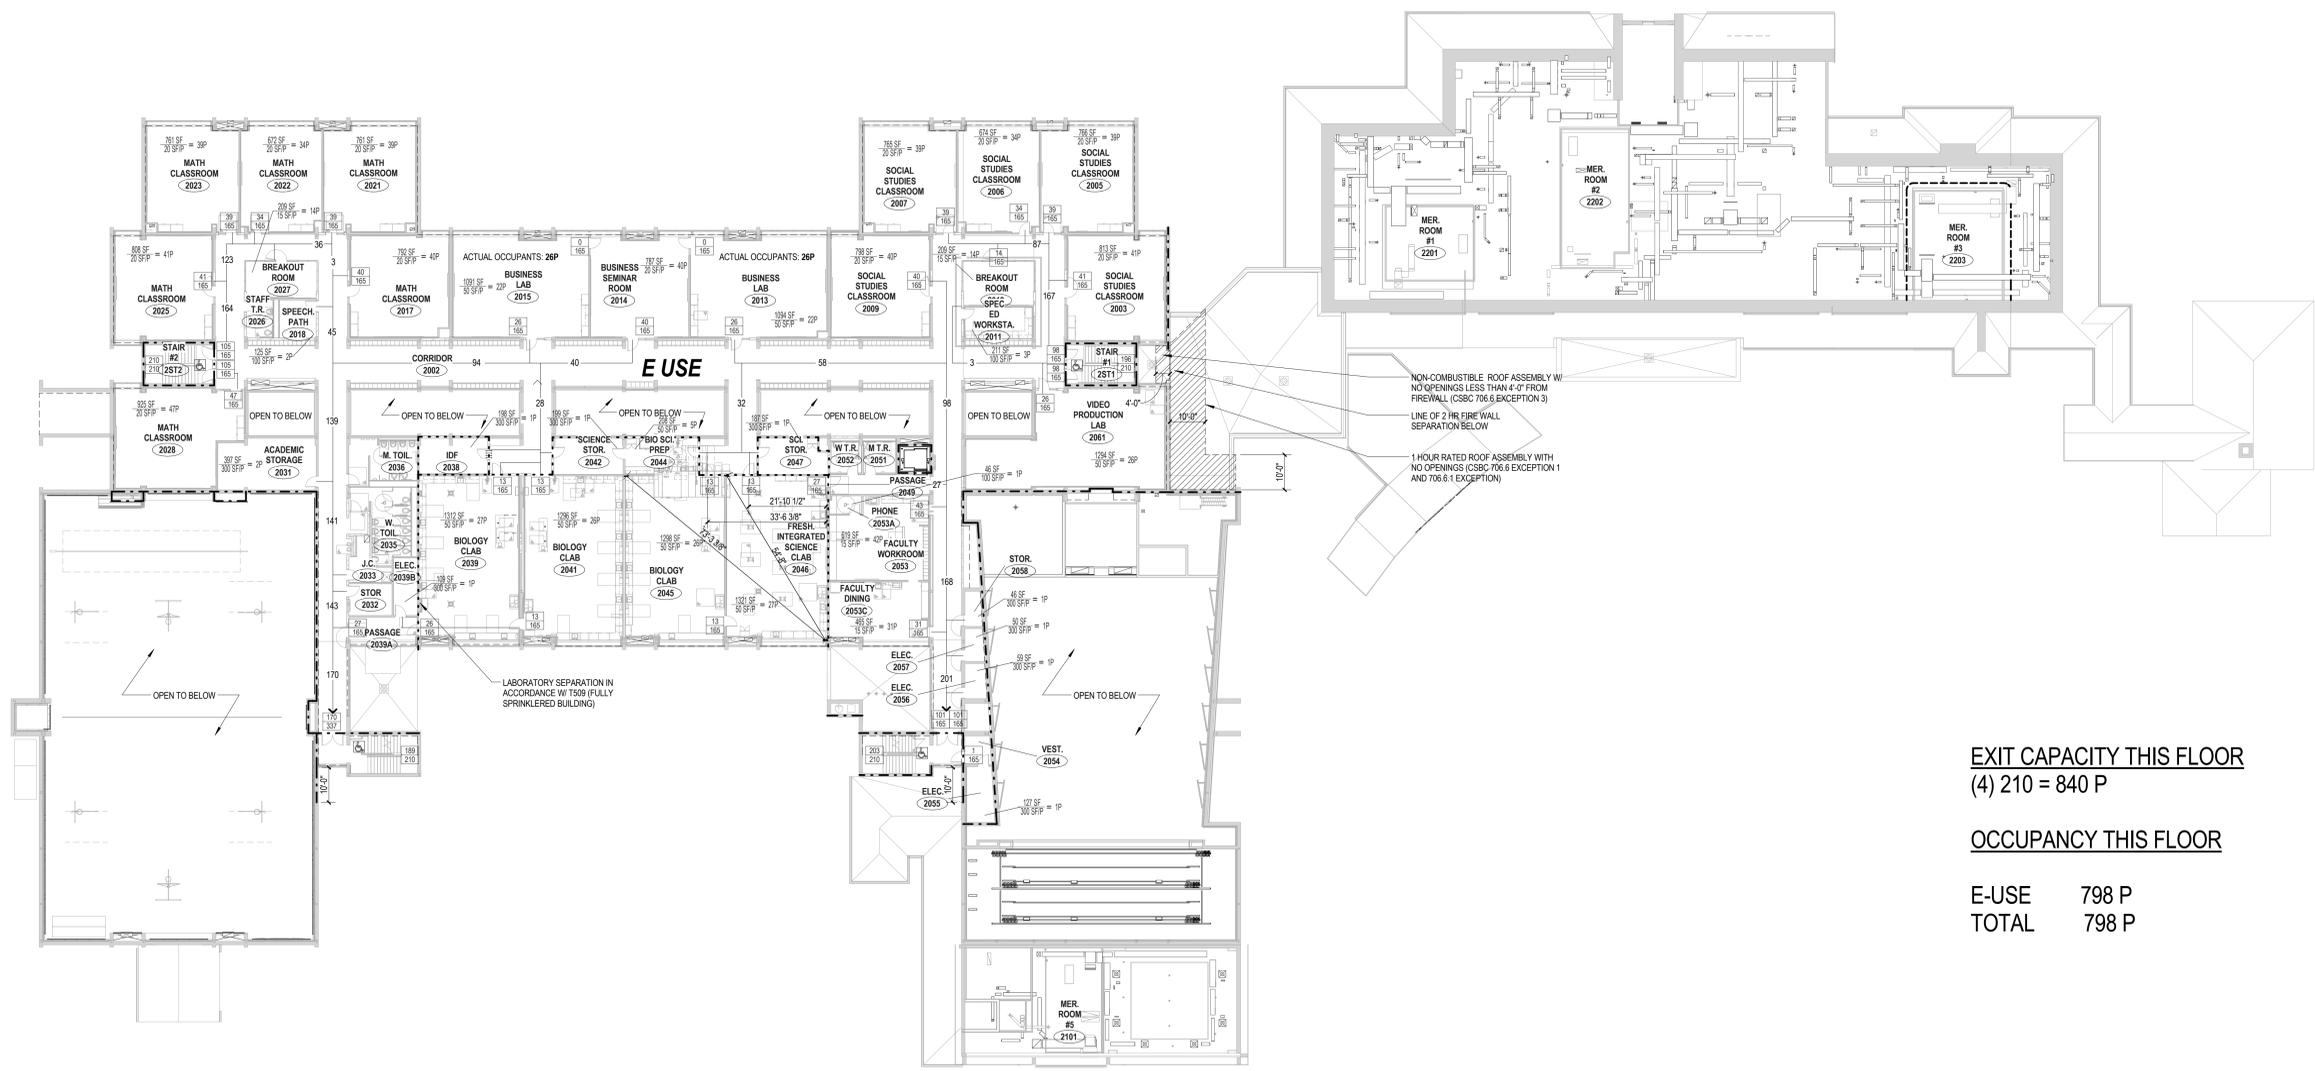

EXIT CAPACITY THIS FLOOR
(4) 210 = 840 P

OCCUPANCY THIS FLOOR

E-USE	798 P
TOTAL	798 P

1 2.0 - SECOND FLOOR FIRE SAFETY PLAN
1" = 20'-0"

FOR REFERENCE ONLY

- FIRE SAFETY LEGEND**
REFER TO FLOOR PLANS AND WALL PARTITION TYPES (DRAWING A601) FOR SPECIFIC PARTITION DETAILS AND LOCATIONS
- ROOM OCCUPANT LOAD**
AREA IN SQ. FT.
OCCUPANT LOAD FACTOR (IBC TABLE 1004.1.2)
- EXIT CAPACITY**
ACTUAL LOAD
EXIT CAPACITY
- DIRECTION OF TRAVEL WITH ACCUMULATED OCCUPANT LOAD**
MAXIMUM TRAVEL DISTANCE FROM FURTHEST POINT
- NON ACCESSIBLE EXIT**
ACCESSIBLE EXIT
- FIRE RATING DESIGNATIONS:**
NON-FIRE RATED SMOKE PARTITION (IBC 710)
1 HOUR RATED WALL
2 HOUR RATED WALL
- GROSS OCCUPANCY AREA FOR BUSINESS USE**
OCCUPANCY AREA FOR ASSEMBLY USE

1

2

3

4

5



A

B

C

D

E

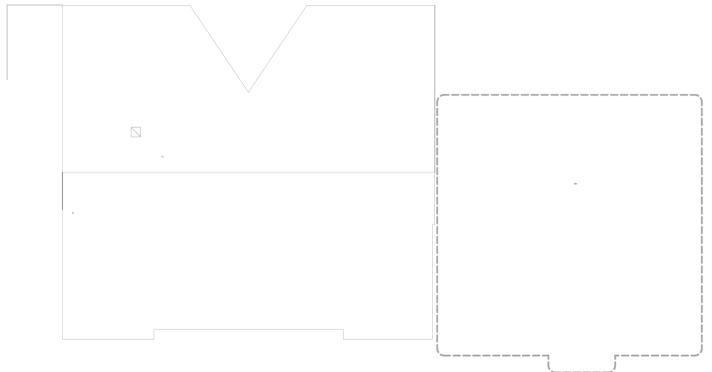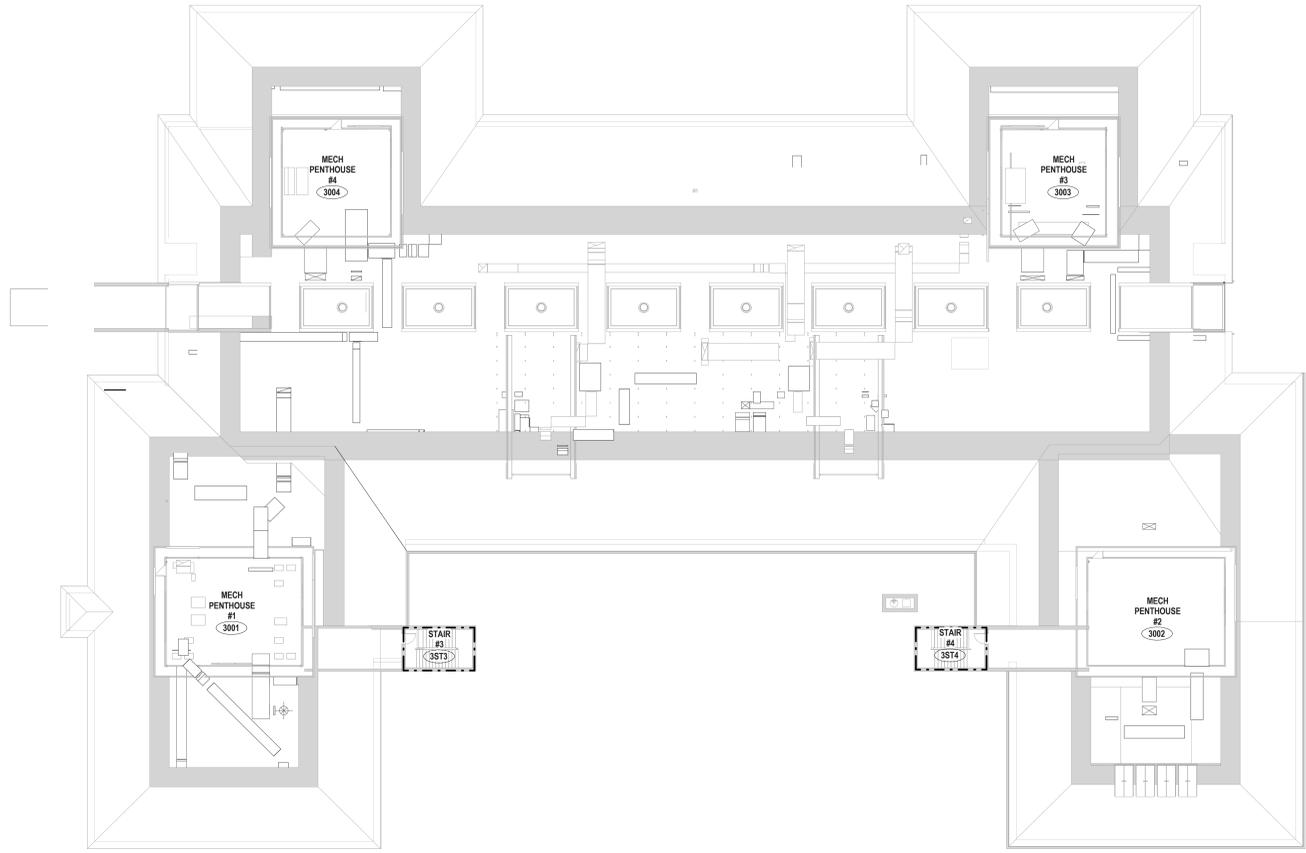

1 2.5 - ATTIC FLOOR FIRE SAFETY PLAN
1" = 20'-0"

FOR REFERENCE ONLY

FIRE SAFETY LEGEND
REFER TO FLOOR PLANS AND WALL PARTITION TYPES (DRAWING A601) FOR SPECIFIC PARTITION DETAILS AND LOCATIONS

FIRE RATING DESIGNATIONS:

- NON-FIRE RATED SMOKE PARTITION (IBC 710)
- 1 HOUR RATED WALL
- 2 HOUR RATED WALL

SLAM
The S/L/A/M Collaborative

80 Glastonbury Blvd
Glastonbury, CT 06033-4410
phone 860 657.8077
fax 860 657.3141

www.slamcoll.com


Drawn
PH, KH

Checked

Region 14 Schools
Inspiring Excellence

NONNEWAUG HIGH SCHOOL
PHASE 2 of 3
SITE AND BUILDING
CONSTRUCTION/RENOVATION
5 MINORTOWN RD
WOODBURY, CT 06798

STATE PROJECT NO. 214-0093 RN
STATE PROJECT NO. 214-0096 BE/A/CV

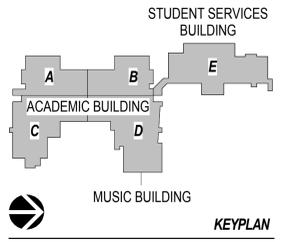

Number	Date	Issued For
	11/15/2017	ISSUED FOR BID

ATTIC FLOOR FIRE SAFETY PLAN

Date: 7/17/2017
Scale: As indicated
Proj. Number: 15232.00

Drawing Number: **GC103**

© 2017 The S/L/A/M Collaborative, Inc. C:\RevitProjects\Nonnewaug_A_SLAM_152016_C\Floor.plt

MATCHLINE - SEE SHEET L201B

1

2

3

4

5


A

B

C

D

E

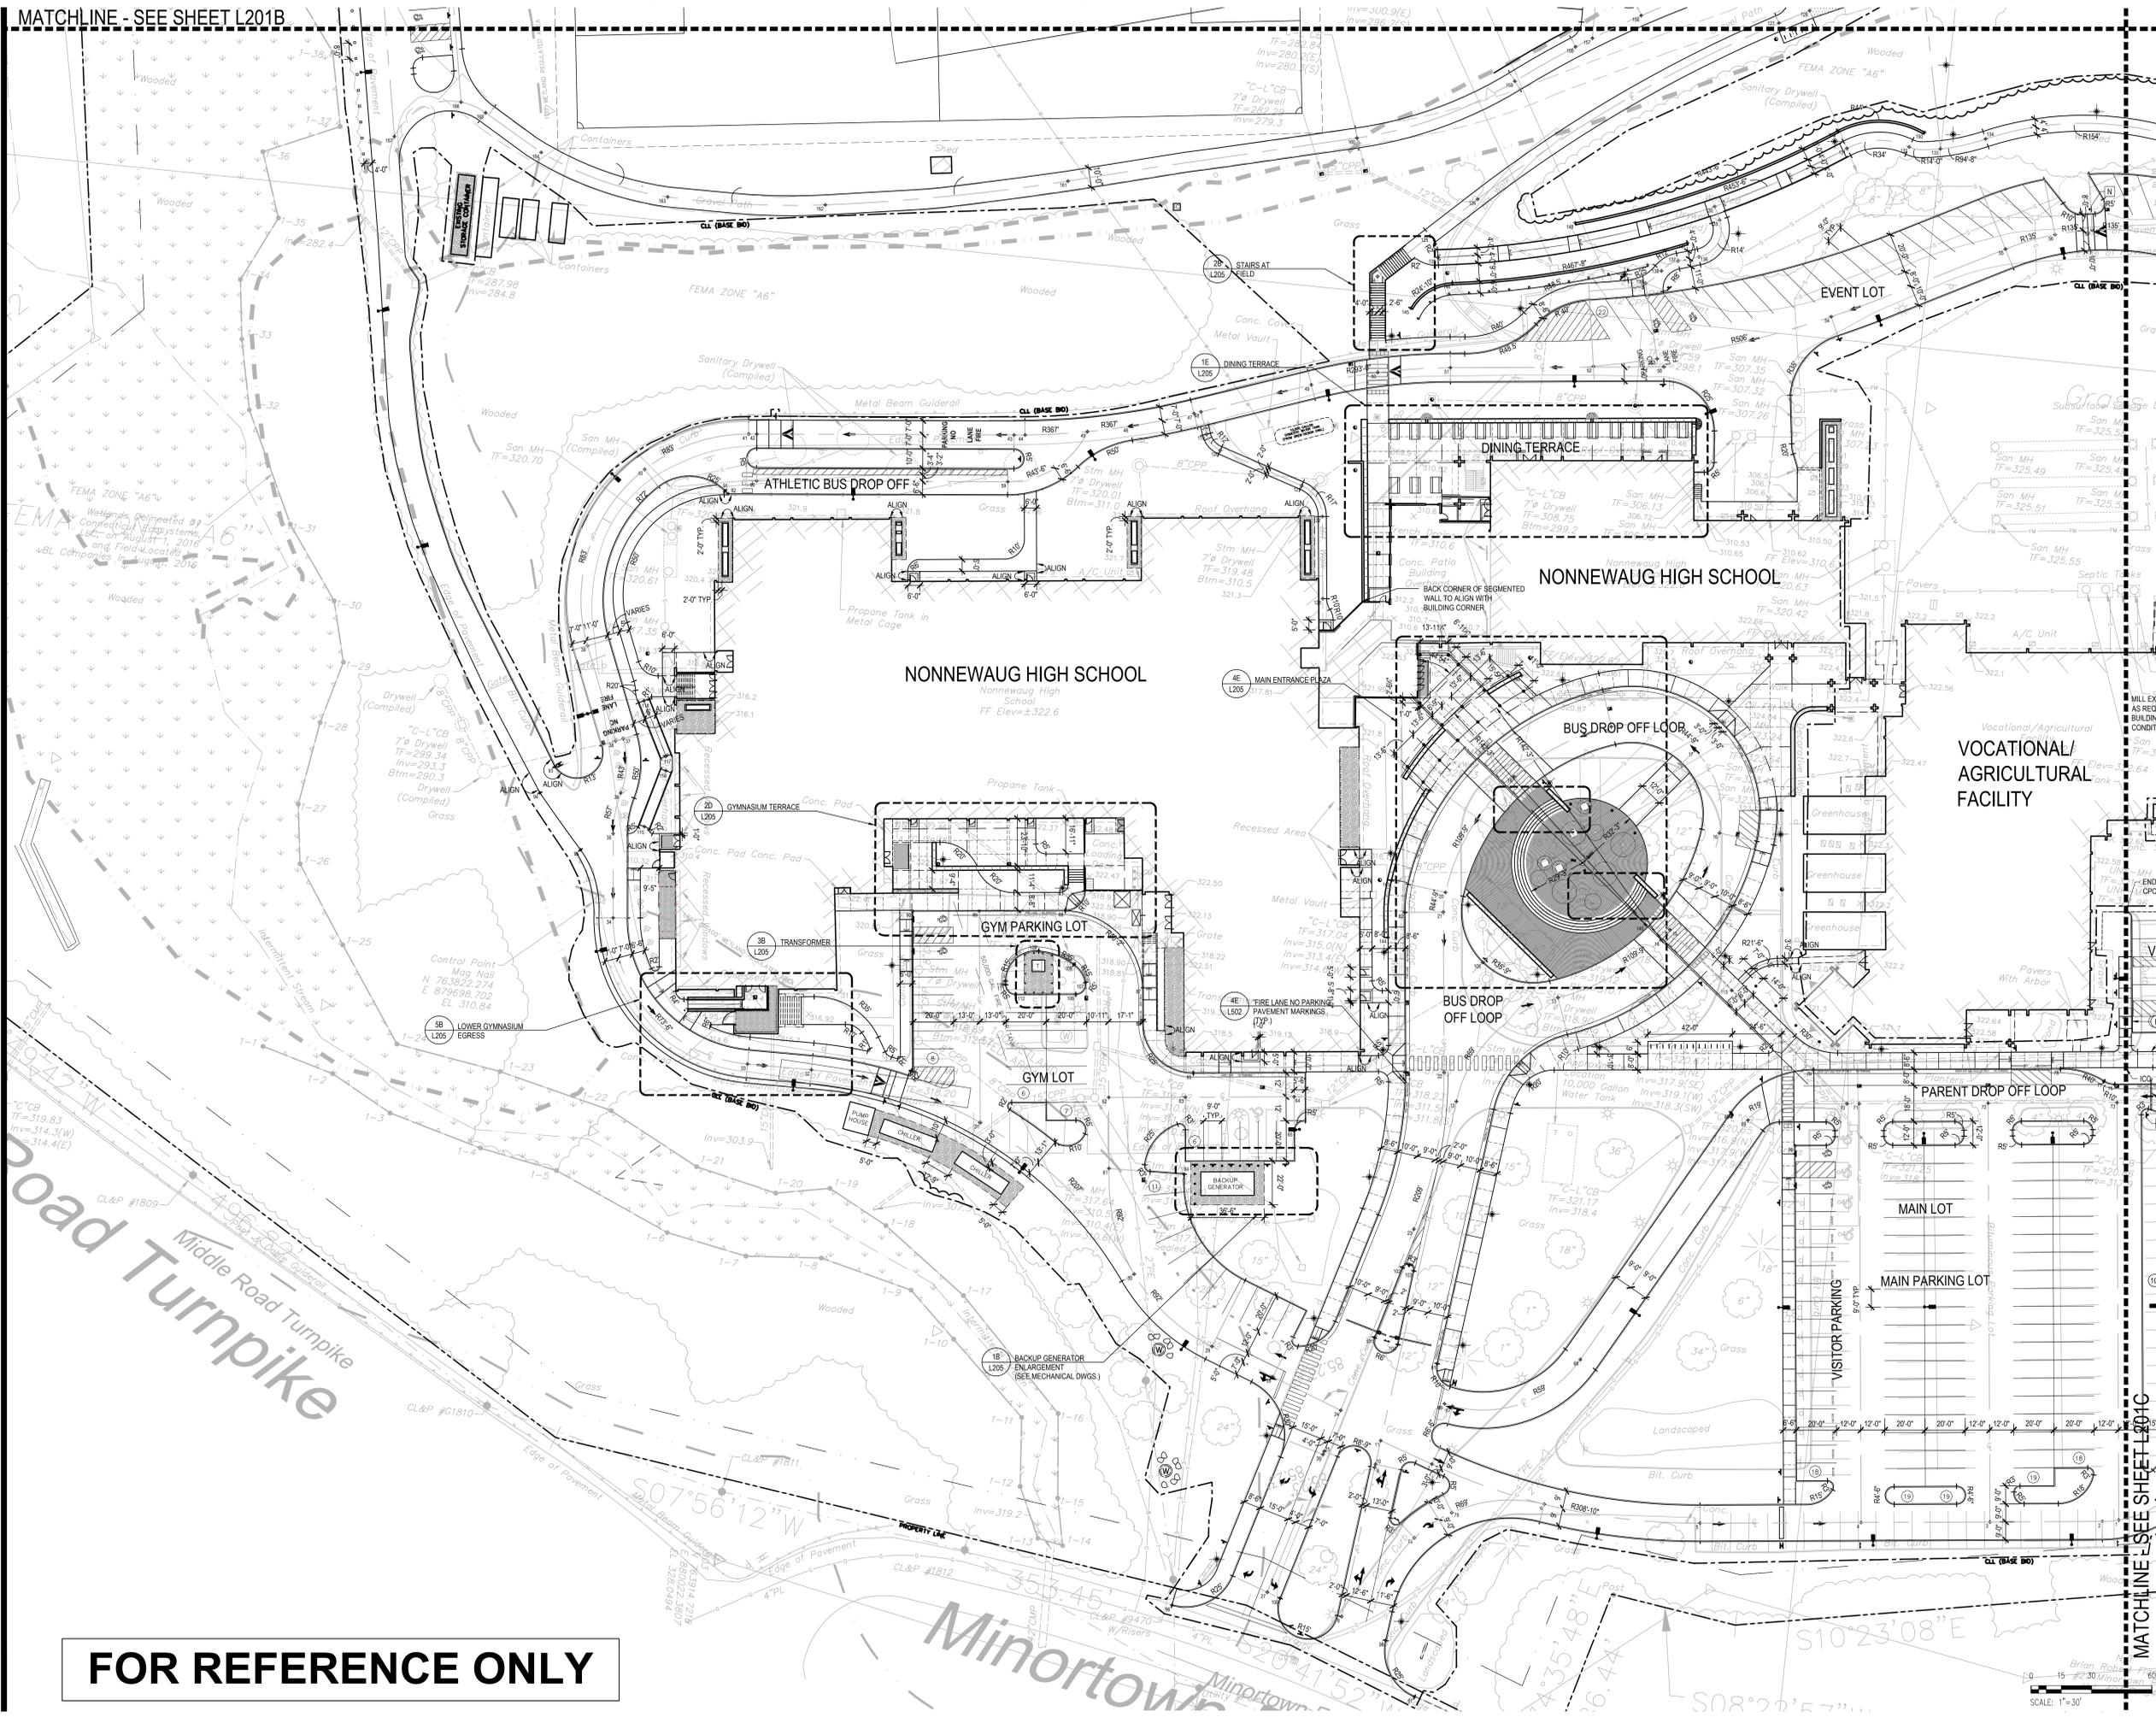

SLAM
The S/I/L/A/M Collaborative

80 Glastonbury Blvd
Glastonbury, CT 06033-4415
phone 860 657.8077
fax 860 657.3141

www.slamcoll.com

Drawn
MP
Checked
TRS



NONNEWAUG HIGH SCHOOL

5 MINORTOWN RD
WOODBURY, CT 06798

Number	Date	Issued For
11/15/2017	ISSUED FOR BID	

SITE LAYOUT PART A

Date
7/17/2017
Scale
1" = 30'
Proj. Number
15232.00

Drawing Number
L201A

FOR REFERENCE ONLY

SCALE: 1"=30'

MATCHLINE - SEE SHEET L201C

P:\Projects\Proj 15232\46-Documentation\2-Drawings\SLAM\L201A_SiteLayout.dwg November 14, 2017 - 11:43 AM

Drawn
PH, KH, CF

Checked




NONNEWAUG HIGH SCHOOL

PHASE 2 of 3
 SITE AND BUILDING
 CONSTRUCTION/RENOVATION

5 MINORTOWN RD
 WOODBURY, CT 06798

STATE PROJECT NO. 214-0093 RN
 STATE PROJECT NO. 214-0096 BE/A/CV

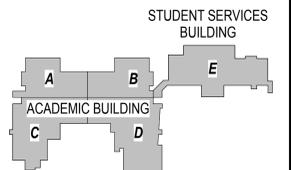

KEYPLAN

Number	Date	Issued For
11/15/2017	ISSUED FOR BID	

OVERALL LOWER LEVEL PLAN

Date
7/17/2017
 Scale
1" = 20'-0"
 Proj. Number
15232.00

Drawing Number
A100

C:\Revit\Projects\Nonnewaug_A_SLAM_22016_CFD.rvt

1

2

3

4

5


A

B

C

D

E

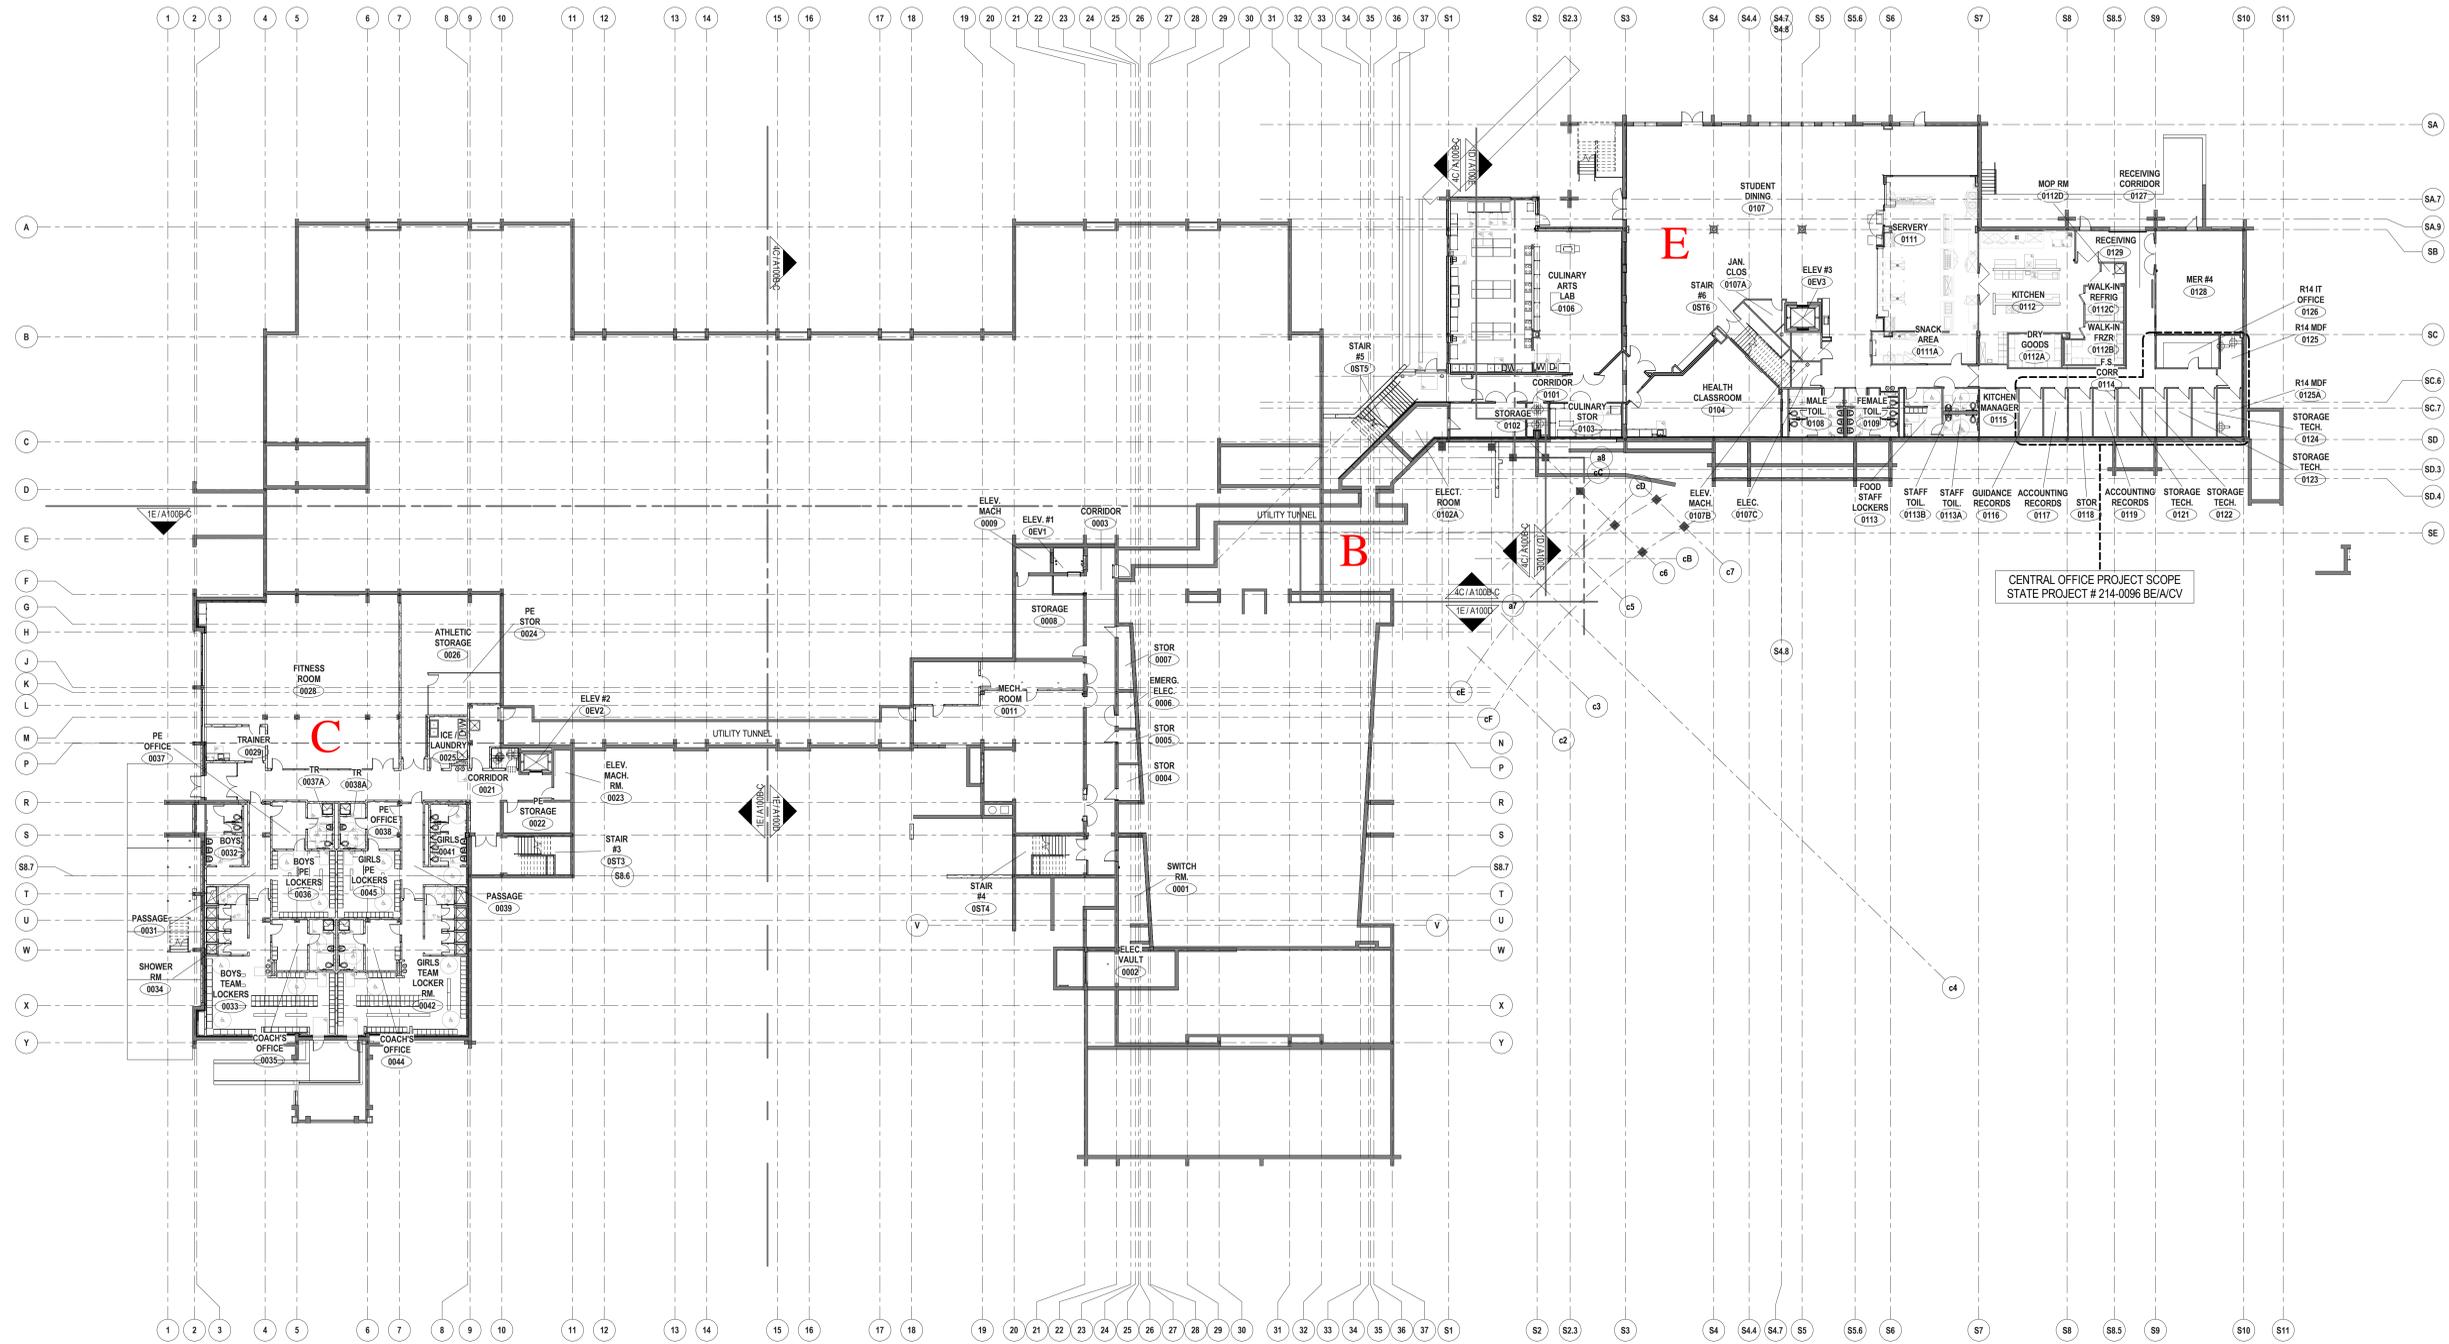

1D OVERALL LOWER LEVEL PLAN
 1" = 20'-0"

FOR REFERENCE ONLY

Drawn
PH, KH, CF

Checked




NONNEWAUG HIGH SCHOOL

PHASE 2 of 3
SITE AND BUILDING
CONSTRUCTION/RENOVATION

5 MINORTOWN RD
WOODBURY, CT 06798

STATE PROJECT NO. 214-0093 RN
STATE PROJECT NO. 214-0096 BE/A/CV

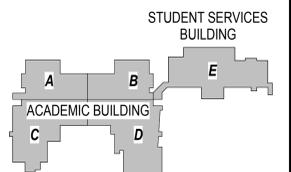

MUSIC BUILDING
KEYPLAN


Number Date Issued For

Number	Date	Issued For
11/15/2017	ISSUED FOR BID	

OVERALL FIRST FLOOR PLAN

Date
7/17/2017
Scale
1" = 20'-0"
Proj. Number
15232.00

Drawing Number
A101

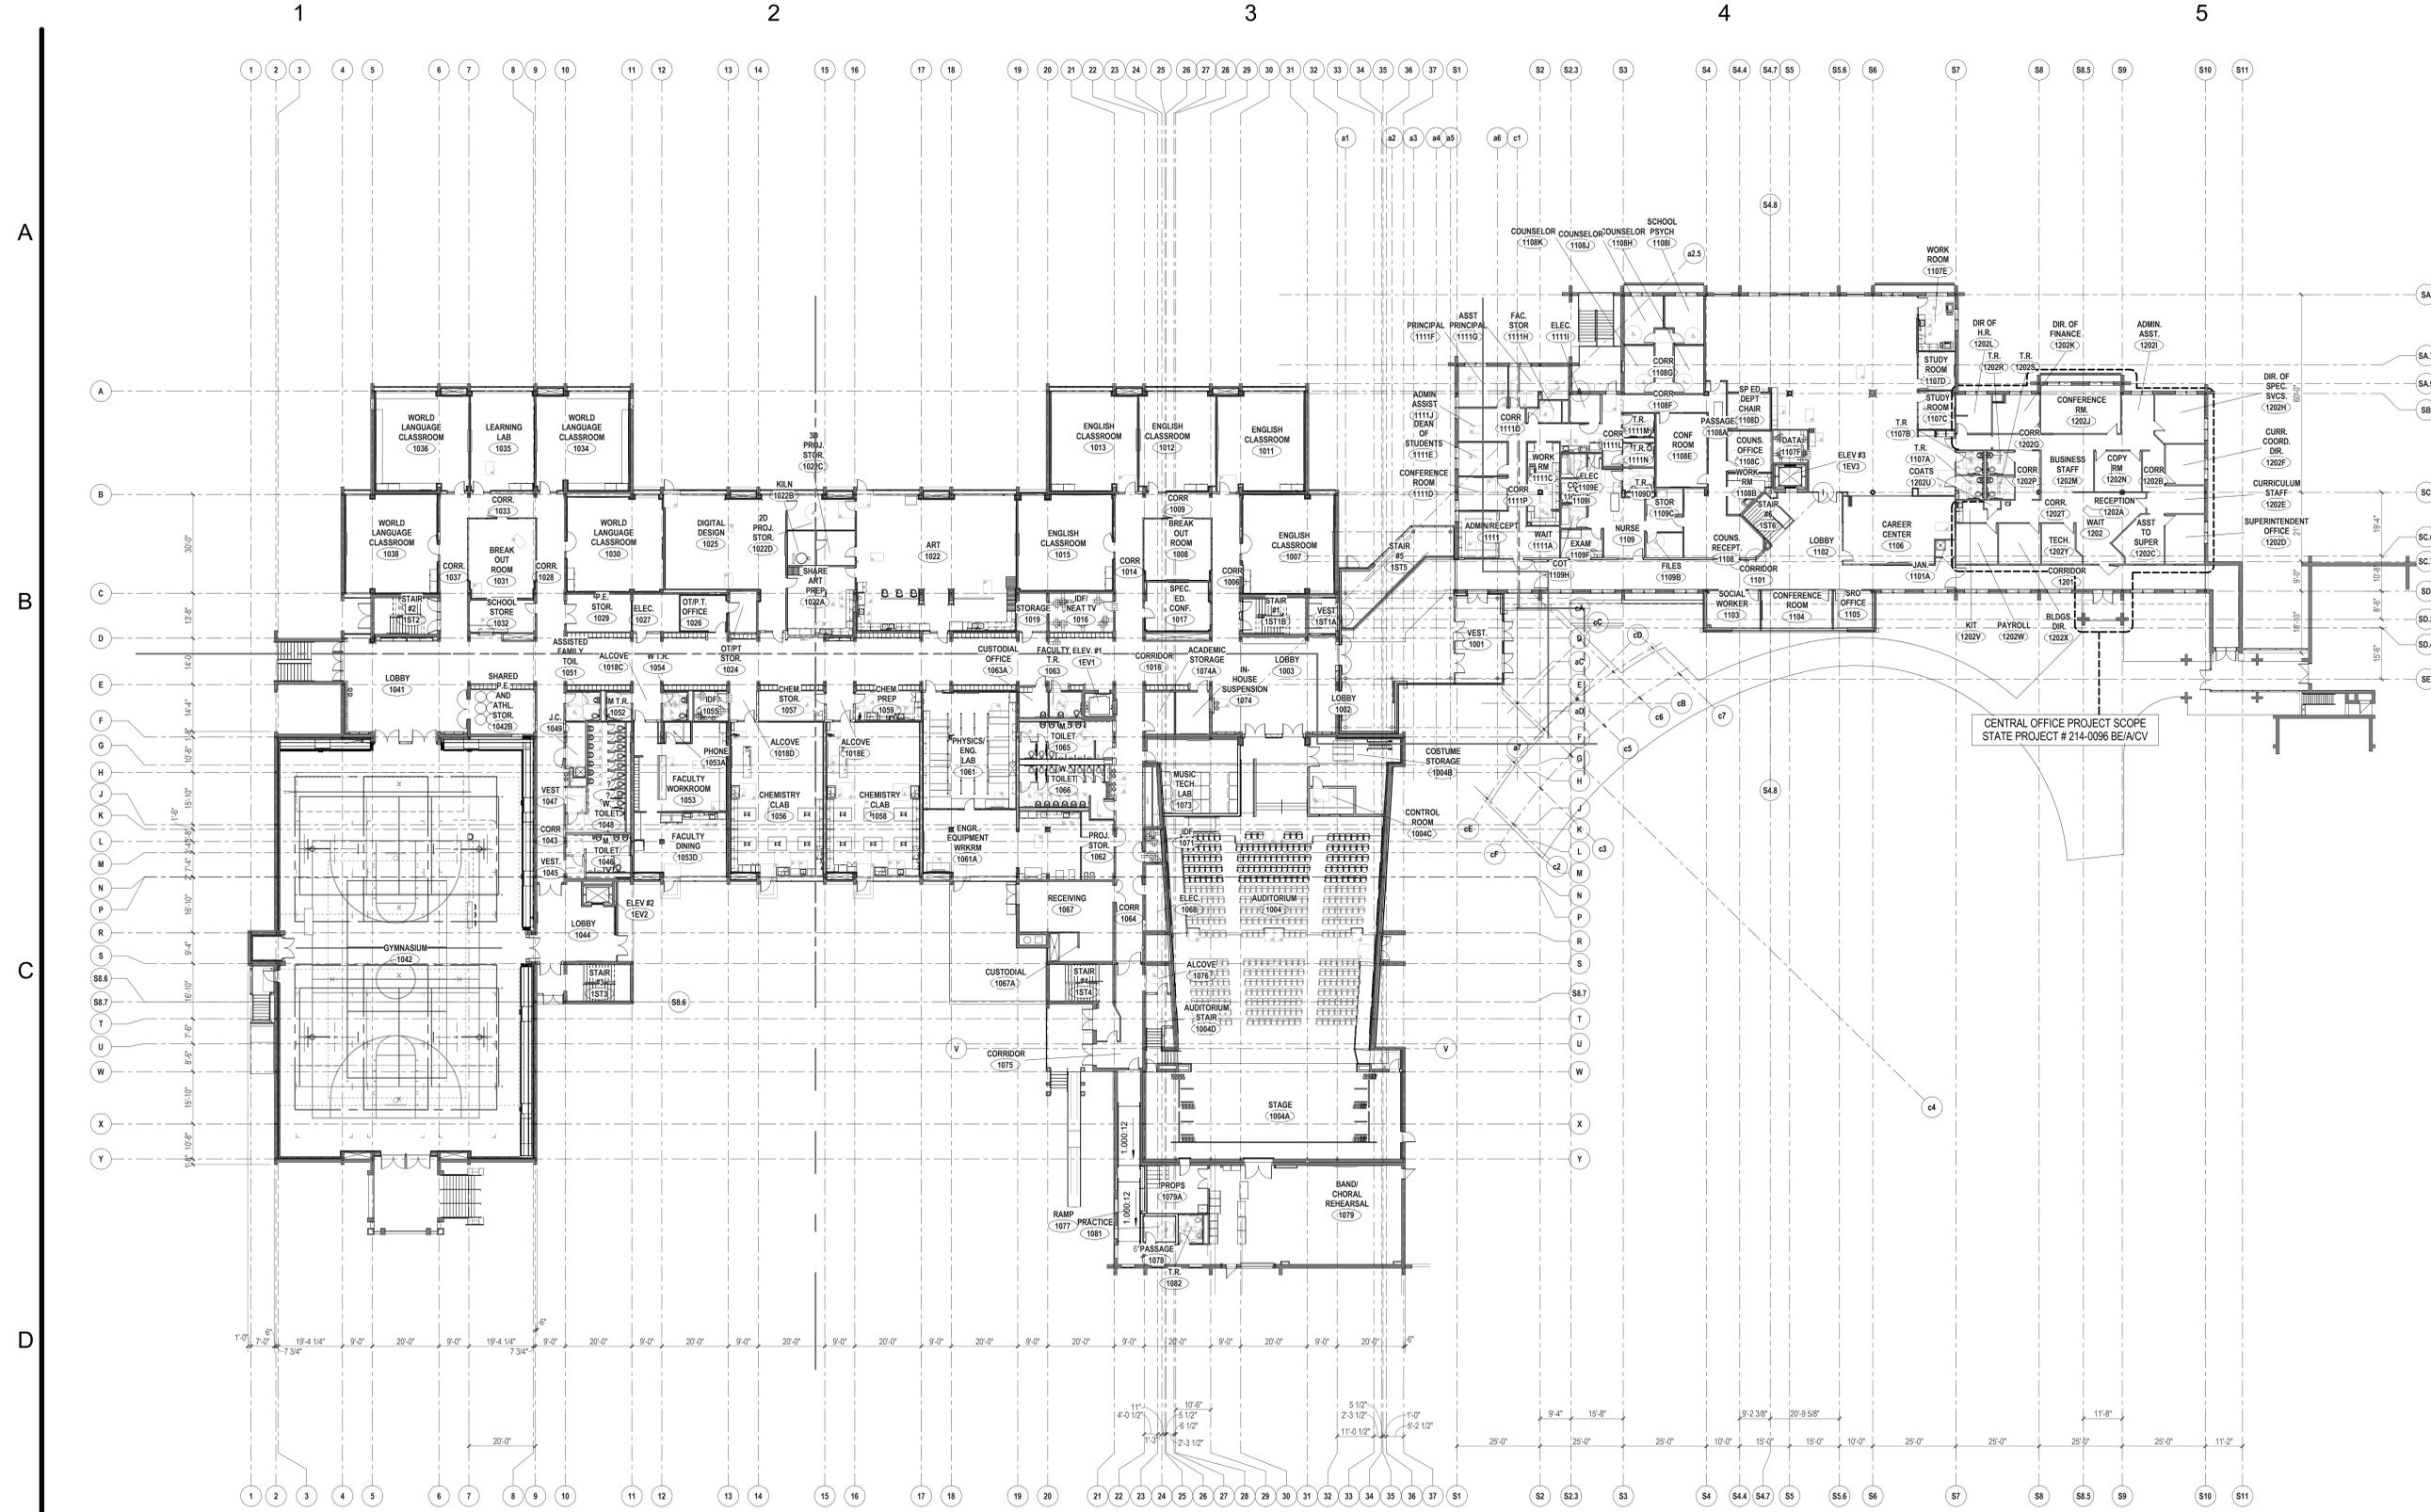

1D OVERALL FIRST FLOOR PLAN
1" = 20'-0"

FOR REFERENCE ONLY


Drawn	Author
Checked	Checker



NONNEWAUG HIGH SCHOOL

PHASE 2 of 3
SITE AND BUILDING
CONSTRUCTION/RENOVATION
5 MINORTOWN RD
WOODBURY, CT 06798

STATE PROJECT NO. 214-0093 RN
STATE PROJECT NO. 214-0096 BE/A/CV

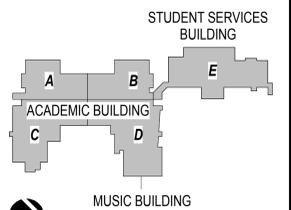


KEYPLAN

Number	Date	Issued For
11/15/2017	ISSUED FOR BID	

OVERALL SECOND FLOOR PLAN

Date	7/17/2017	Drawing Number	A102
Scale	1" = 20'-0"		
Proj. Number	15232.00		

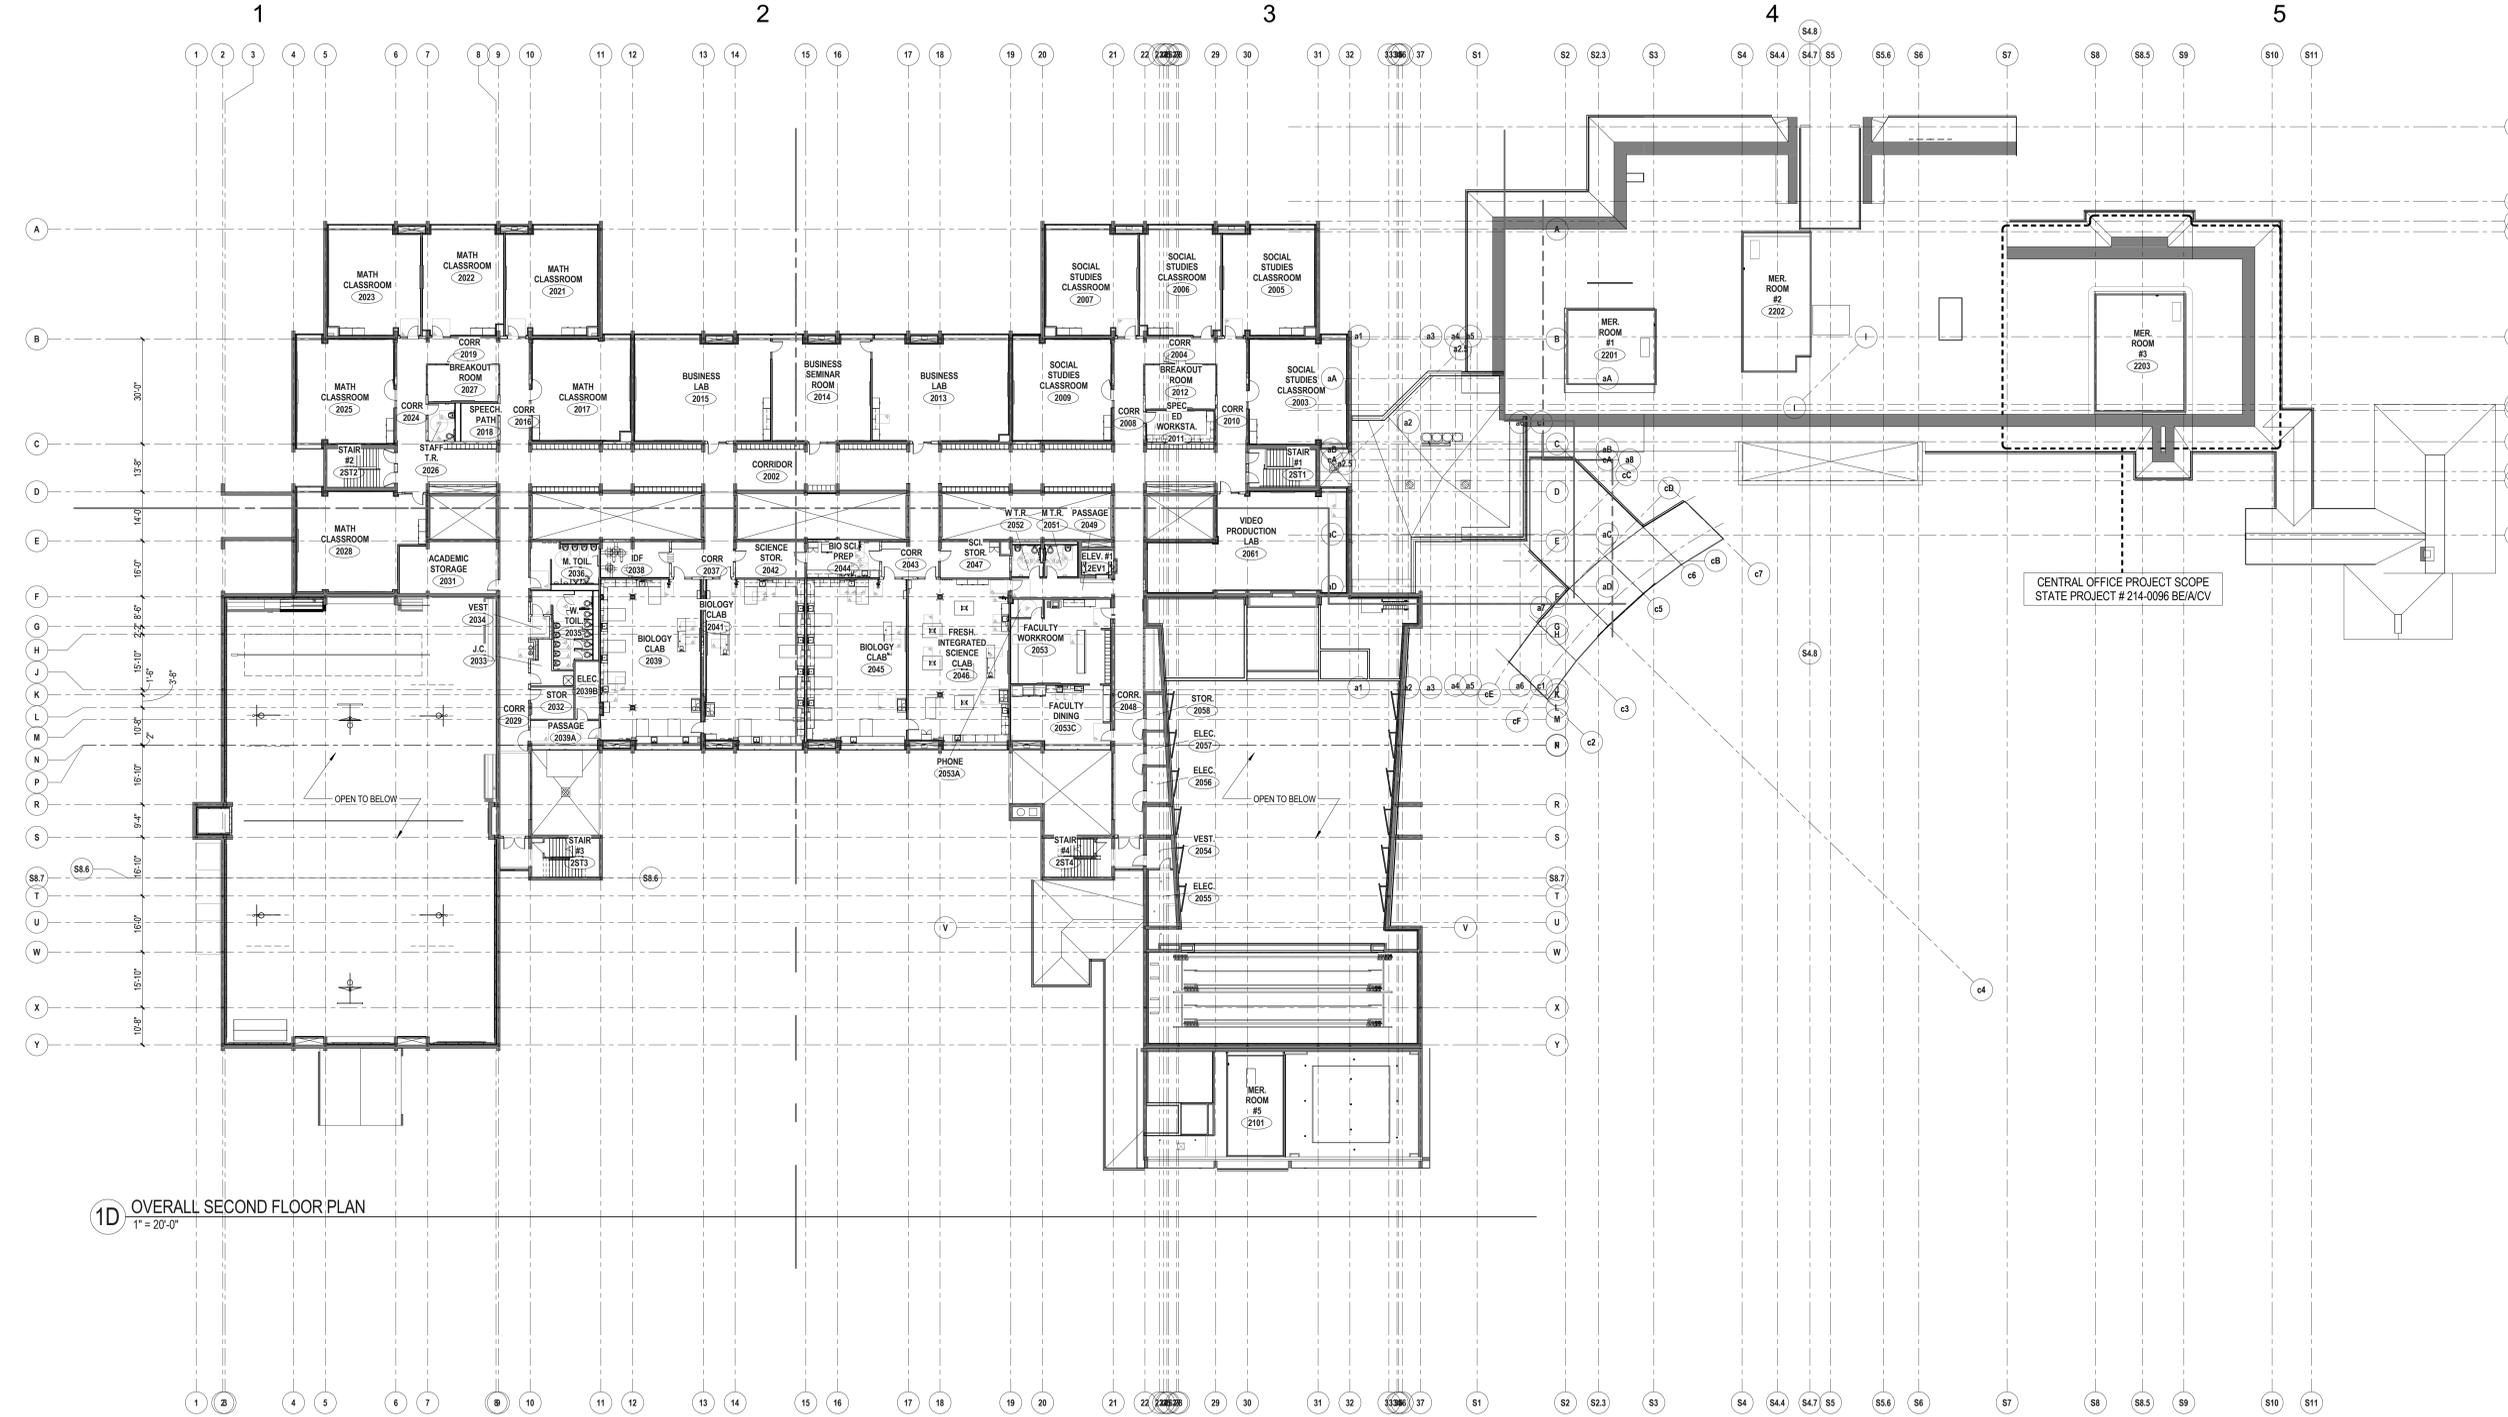

1D OVERALL SECOND FLOOR PLAN
1" = 20'-0"

FOR REFERENCE ONLY


A

B

C

D


E

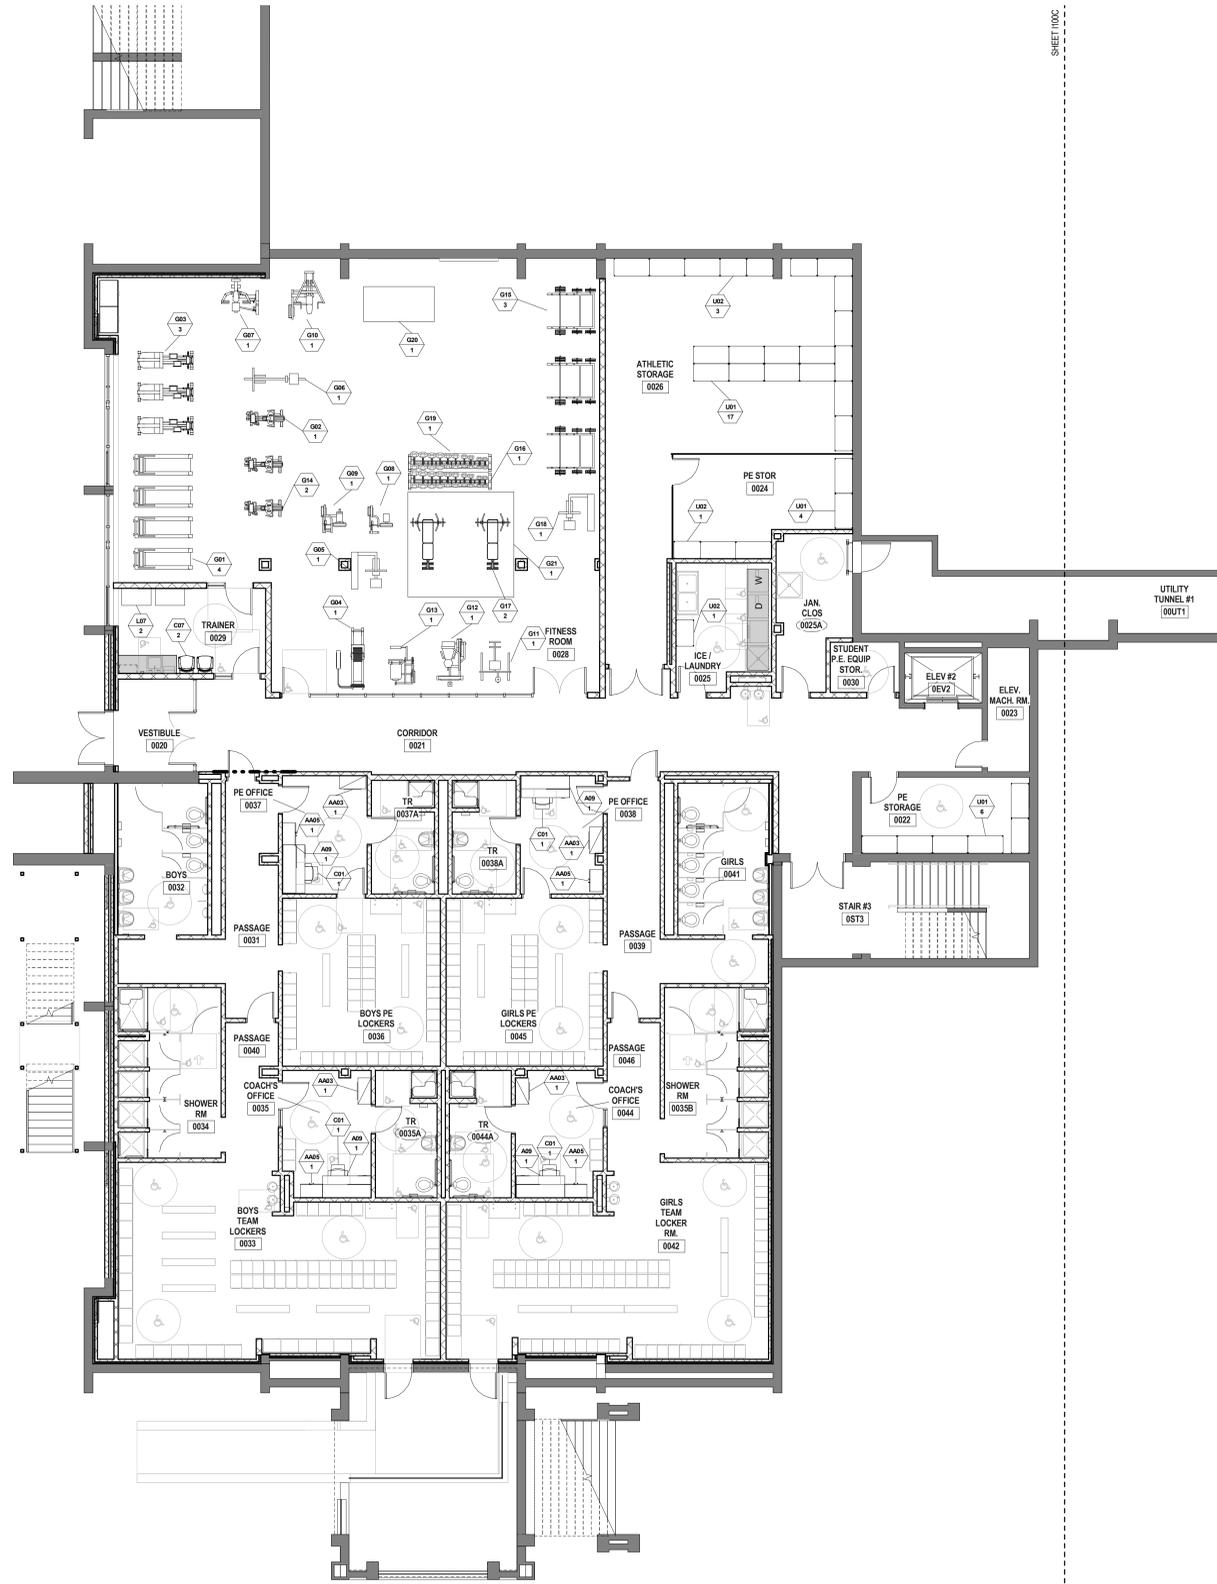


SHEET 1100C

1 LOWER LEVEL FURNITURE PLAN - PART C
1/8" = 1'-0"

ADA COMPLIANT CLEARANCES FOR ADULTS:

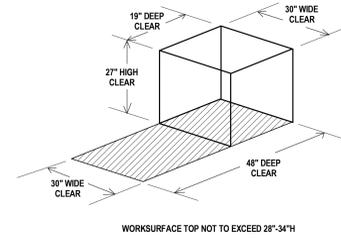

ADA COMPLIANT CLEARANCES FOR CHILDREN:

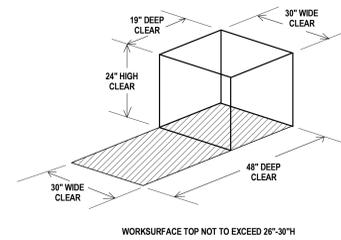

CODE COMPLIANCE NOTE:

In order to meet the needs of persons with disabilities, when applicable all items shall comply with the current Connecticut Basic Building Code including 2003 ICC/ANSI A117.1, Section 504 Rehabilitation Act 1973, including the 2010 ADA Standards for Accessible Design and Section 504 Regulations, and the Americans with Disabilities Act Title II, including the 2010 ADA Standards for Accessible Design and ADA Regulations. Accessible knee and toe clearances shall comply with 2010 ADA Standards for Accessible Design, Section 306. Compliance with the current Connecticut Fire Safety Code and current O.S.H.A. - Title 29 Labor is also required. The items shall include, but are not limited to: fixtures, furnishings, equipment, workstations (including built-ins), playground equipment, laboratory fume hoods, darkroom equipment, welding stations, shop equipment and etc. Secure Attachment of FF&E Items

SECURE ATTACHMENT NOTE:

To ensure proper attachment of Fixtures, Furnishings & Equipment items, including Technology items, where "Items" are attached to wall, ceiling, and/or floor. Contractor shall provide information adequate to verify that fixtures, furnishings and equipment attached to wall, ceiling and/or floor are attached securely. Architect's review may be implemented during submittal process.

Contractor shall provide struts, hangers, fasteners, safety harnesses, channels, bolts, screws, rods, and etc. to securely attach items to existing structure as required to meet field conditions and meet applicable code.

*REFER TO FURNITURE SCHEDULE BY ROOM ON SHEET I200 FOR COMPLETE LIST OF ALL FF&E ITEMS IN ALL ROOMS

ITEMS SHOWN SHADED ARE PART OF THE CONSTRUCTION PACKAGE (INCLUDING MILLWORK, CASEWORK AND EQUIPMENT) AND ARE FOR REFERENCE ONLY.

Drawn AH	
Checked Checker	




NONNEWAUG HIGH SCHOOL

PHASE 3 of 3
FIXTURES, FURNISHINGS & EQUIPMENT

5 MINORTOWN RD
WOODBURY, CT 06798

STATE PROJECT NO. 214-0093 RN
STATE PROJECT NO. 214-0096 BE/A/CV

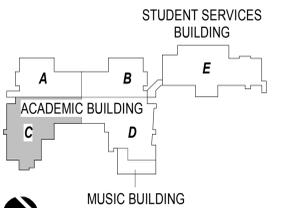

KEYPLAN

Number	Date	Issued For

LOWER LEVEL FURNITURE PLAN - PART C

Date 01-12-2018	Drawing Number I100C
Scale As indicated	Proj. Number 15232.00

1

2

3

4

5


A

B

C


D

E

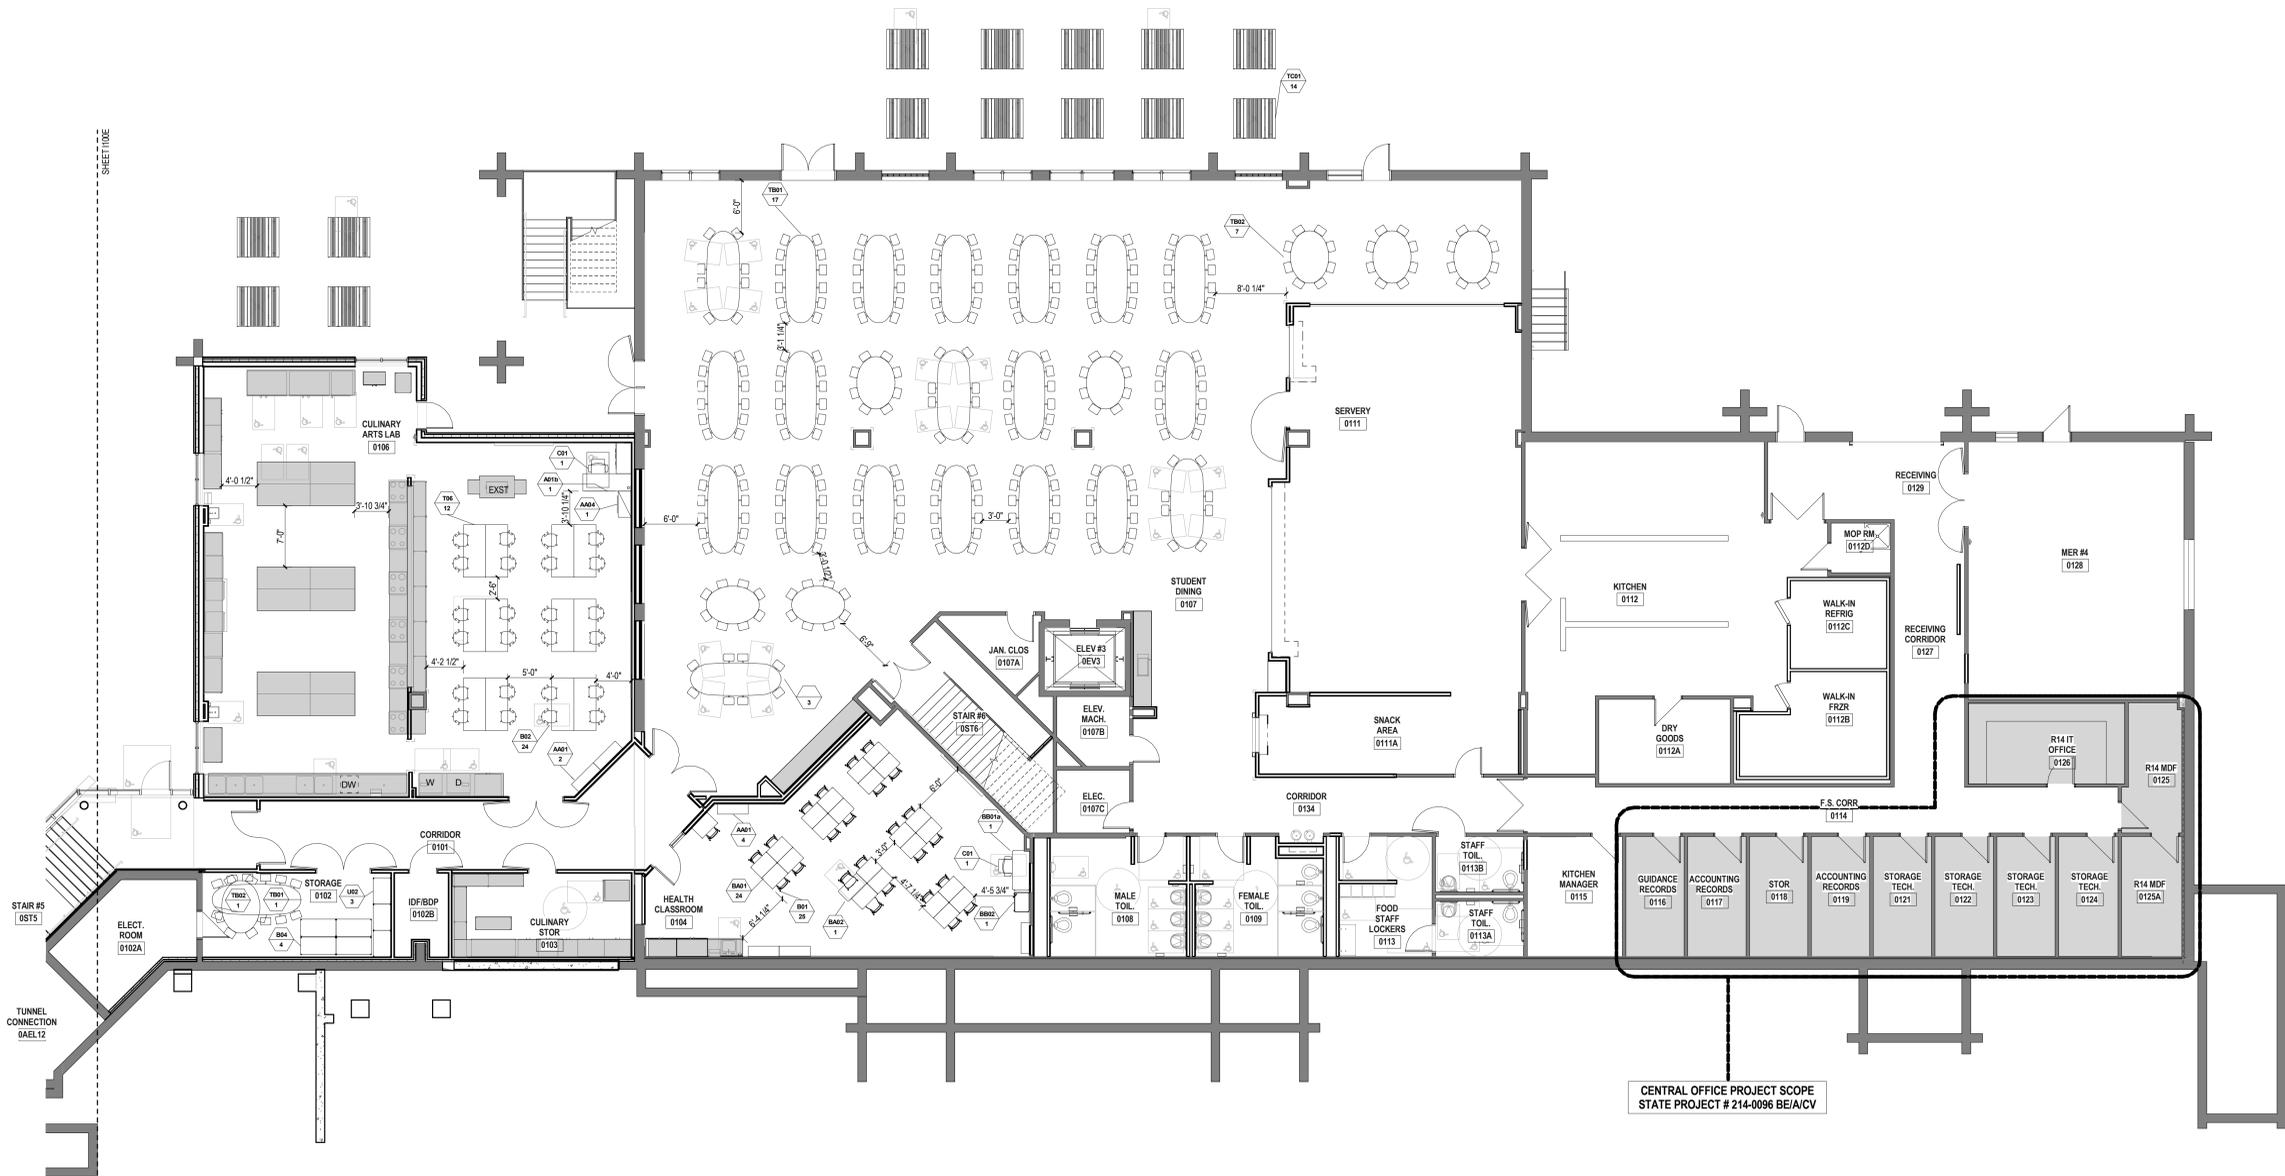


1 LOWER LEVEL FURNITURE PLAN - PART E
1/8" = 1'-0"

ADA COMPLIANT CLEARANCES FOR ADULTS:

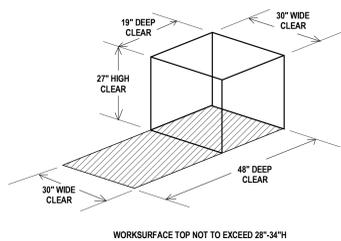

ADA COMPLIANT CLEARANCES FOR CHILDREN:

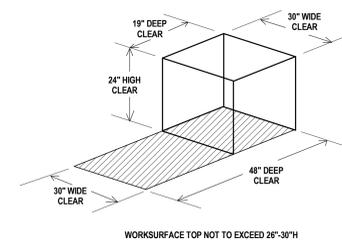

CODE COMPLIANCE NOTE:

In order to meet the needs of persons with disabilities, when applicable all items shall comply with the current Connecticut Basic Building Code including 2003 ICC/ANSI A117.1, Section 044 Rehabilitation Act 1973, including the 2010 ADA Standards for Accessible Design and Section 204 Regulations, and the Americans with Disabilities Act Title II, including the 2010 ADA Standards for Accessible Design and ADA Regulations. Accessible knee and toe clearances shall comply with 2010 ADA Standards for Accessible Design, Section 306. Compliance with the current Connecticut Fire Safety Code and current O.S.H.A. - Title 29 Labor is also required. The items shall include, but are not limited to, fixtures, furnishings, equipment, workstations (including built-ins), playground equipment, laboratory fume hoods, classroom equipment, welding stations, shop equipment and etc. Secure Attachment of FF&E Items

SECURE ATTACHMENT NOTE:

To ensure proper attachment of Fixtures, Furnishings & Equipment items, including Technology items, where "Items" are attached to wall, ceiling, and/or floor, Contractor shall provide information adequate to verify that fixtures, furnishings and equipment attached to wall, ceiling and/or floor are attached securely. Architect's review may be implemented during submittal process.

Contractor shall provide studs, hangers, fasteners, safety harnesses, channels, bolts, screws, rods, and etc. to securely attach items to existing structure as required to meet field conditions and meet applicable code.

*REFER TO FURNITURE SCHEDULE BY ROOM ON SHEET I200 FOR COMPLETE LIST OF ALL FF&E ITEMS IN ALL ROOMS
ITEMS SHOWN SHADED ARE PART OF THE CONSTRUCTION PACKAGE (INCLUDING MILLWORK, CASEWORK, AND EQUIPMENT) AND ARE FOR REFERENCE ONLY.

Drawn AH	
Checked Checker	




NONNEWAUG HIGH SCHOOL

PHASE 3 of 3
FIXTURES, FURNISHINGS & EQUIPMENT

5 MINORTOWN RD
WOODBURY, CT 06798

STATE PROJECT NO. 214-0093 RN
STATE PROJECT NO. 214-0096 BE/ACV

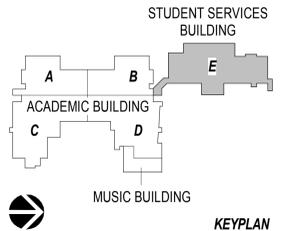

KEYPLAN

Number	Date	Issued For

LOWER LEVEL FURNITURE PLAN - PART E

Date 01-12-2018	Drawing Number
Scale As indicated	I100E
Proj. Number 15232.00	

© 2018 The SLAM Collaborative, Inc.
C:\Revit\Projects\Nonnewaug_A_SLAM_02018_1aastings@slamcoll.com.rvt


Drawn AH	
Checked Checker	



NONNEWAUG HIGH SCHOOL PHASE 3 of 3 FIXTURES, FURNISHINGS & EQUIPMENT

5 MINORTOWN RD
WOODBURY, CT 06798

STATE PROJECT NO. 214-0093 RN
STATE PROJECT NO. 214-0096 BE/A/CV

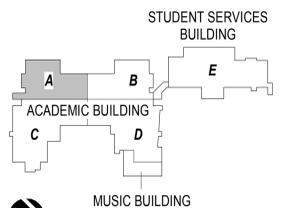


KEYPLAN

Number	Date	Issued For


FIRST FLOOR FURNITURE PLAN - PART A

Date	01-12-2018	Drawing Number	I101A
Scale	As indicated	Proj. Number	15232.00

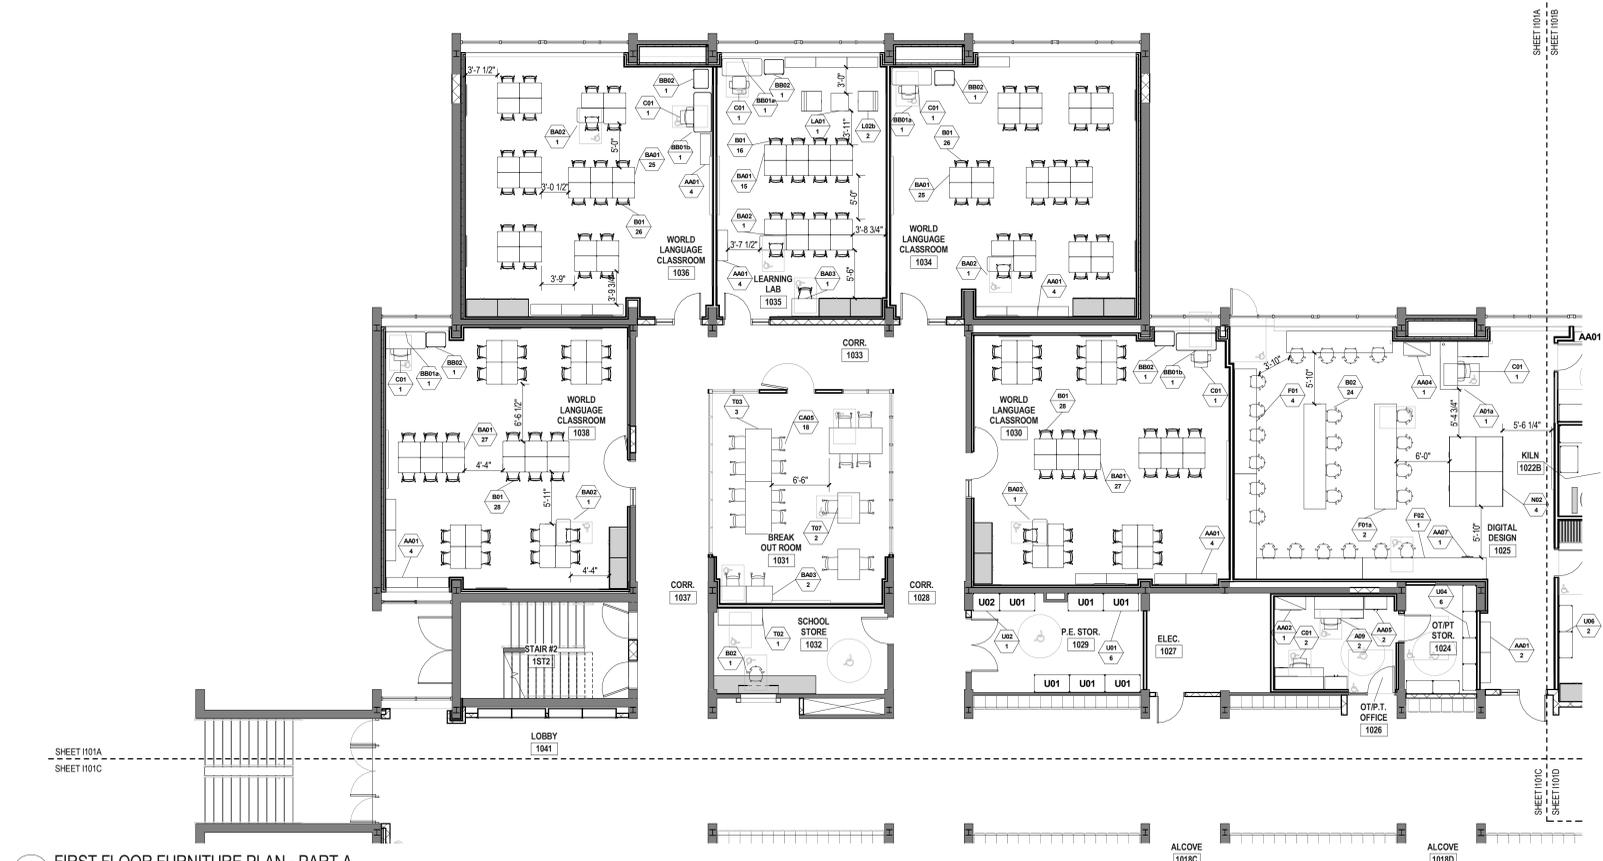


1 FIRST FLOOR FURNITURE PLAN - PART A
1/8" = 1'-0"

ADA COMPLIANT CLEARANCES FOR ADULTS:

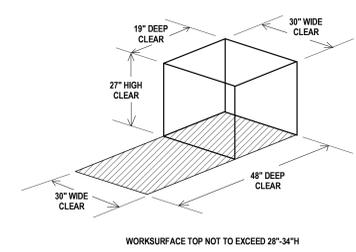

ADA COMPLIANT CLEARANCES FOR CHILDREN:

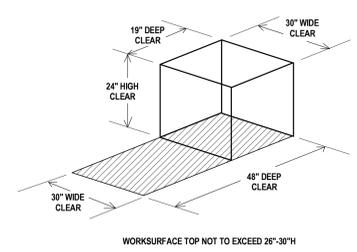

CODE COMPLIANCE NOTE:

In order to meet the needs of persons with disabilities, when applicable all items shall comply with the current Connecticut Basic Building Code including 2003 ICC ANS A117.1, Section 504 Rehabilitation Act 1973, including the 2010 ADA Standards for Accessible Design and Section 504 Regulations, and the Americans with Disabilities Act Title II, including the 2010 ADA Standards for Accessible Design and ADA Regulations. Accessible knee and toe clearances shall comply with 2010 ADA Standards for Accessible Design, Section 306. Compliance with the current Connecticut Fire Safety Code and current O.S.A. Title 201a code is also required. The items shall include, but are not limited to, fixtures, furnishings, equipment, workstations (including built-ins), playground equipment, laboratory fume hoods, darkroom equipment, welding stations, shop equipment and etc. Secure Attachment of FF&E Items

SECURE ATTACHMENT NOTE:

To ensure proper attachment of Fixtures, Furnishings & Equipment items, including Technology items, where "Items" are attached to wall, ceiling, and/or floor. Contractor shall provide information adequate to verify that fixtures, furnishings and equipment attached to wall, ceiling and/or floor are attached securely. Architect's review may be implemented during submittal process. Contractor shall provide struts, hangers, fasteners, safety harnesses, channels, bolts, screws, rods, and etc. to securely attach items to existing structure as required to meet field conditions and meet applicable code.

*REFER TO FURNITURE SCHEDULE BY ROOM ON SHEET I200 FOR COMPLETE LIST OF ALL FF&E ITEMS IN ALL ROOMS
ITEMS SHOWN SHADED ARE PART OF THE CONSTRUCTION PACKAGE (INCLUDING MILLWORK, CASEWORK, AND EQUIPMENT) AND ARE FOR REFERENCE ONLY.

C:\Revit\Projects\Nonnewaug_A_SLAM_02018_Hastings@slamcoll.com.rvt 1/23/2018 3:12:25 PM


A

B


C

D


E

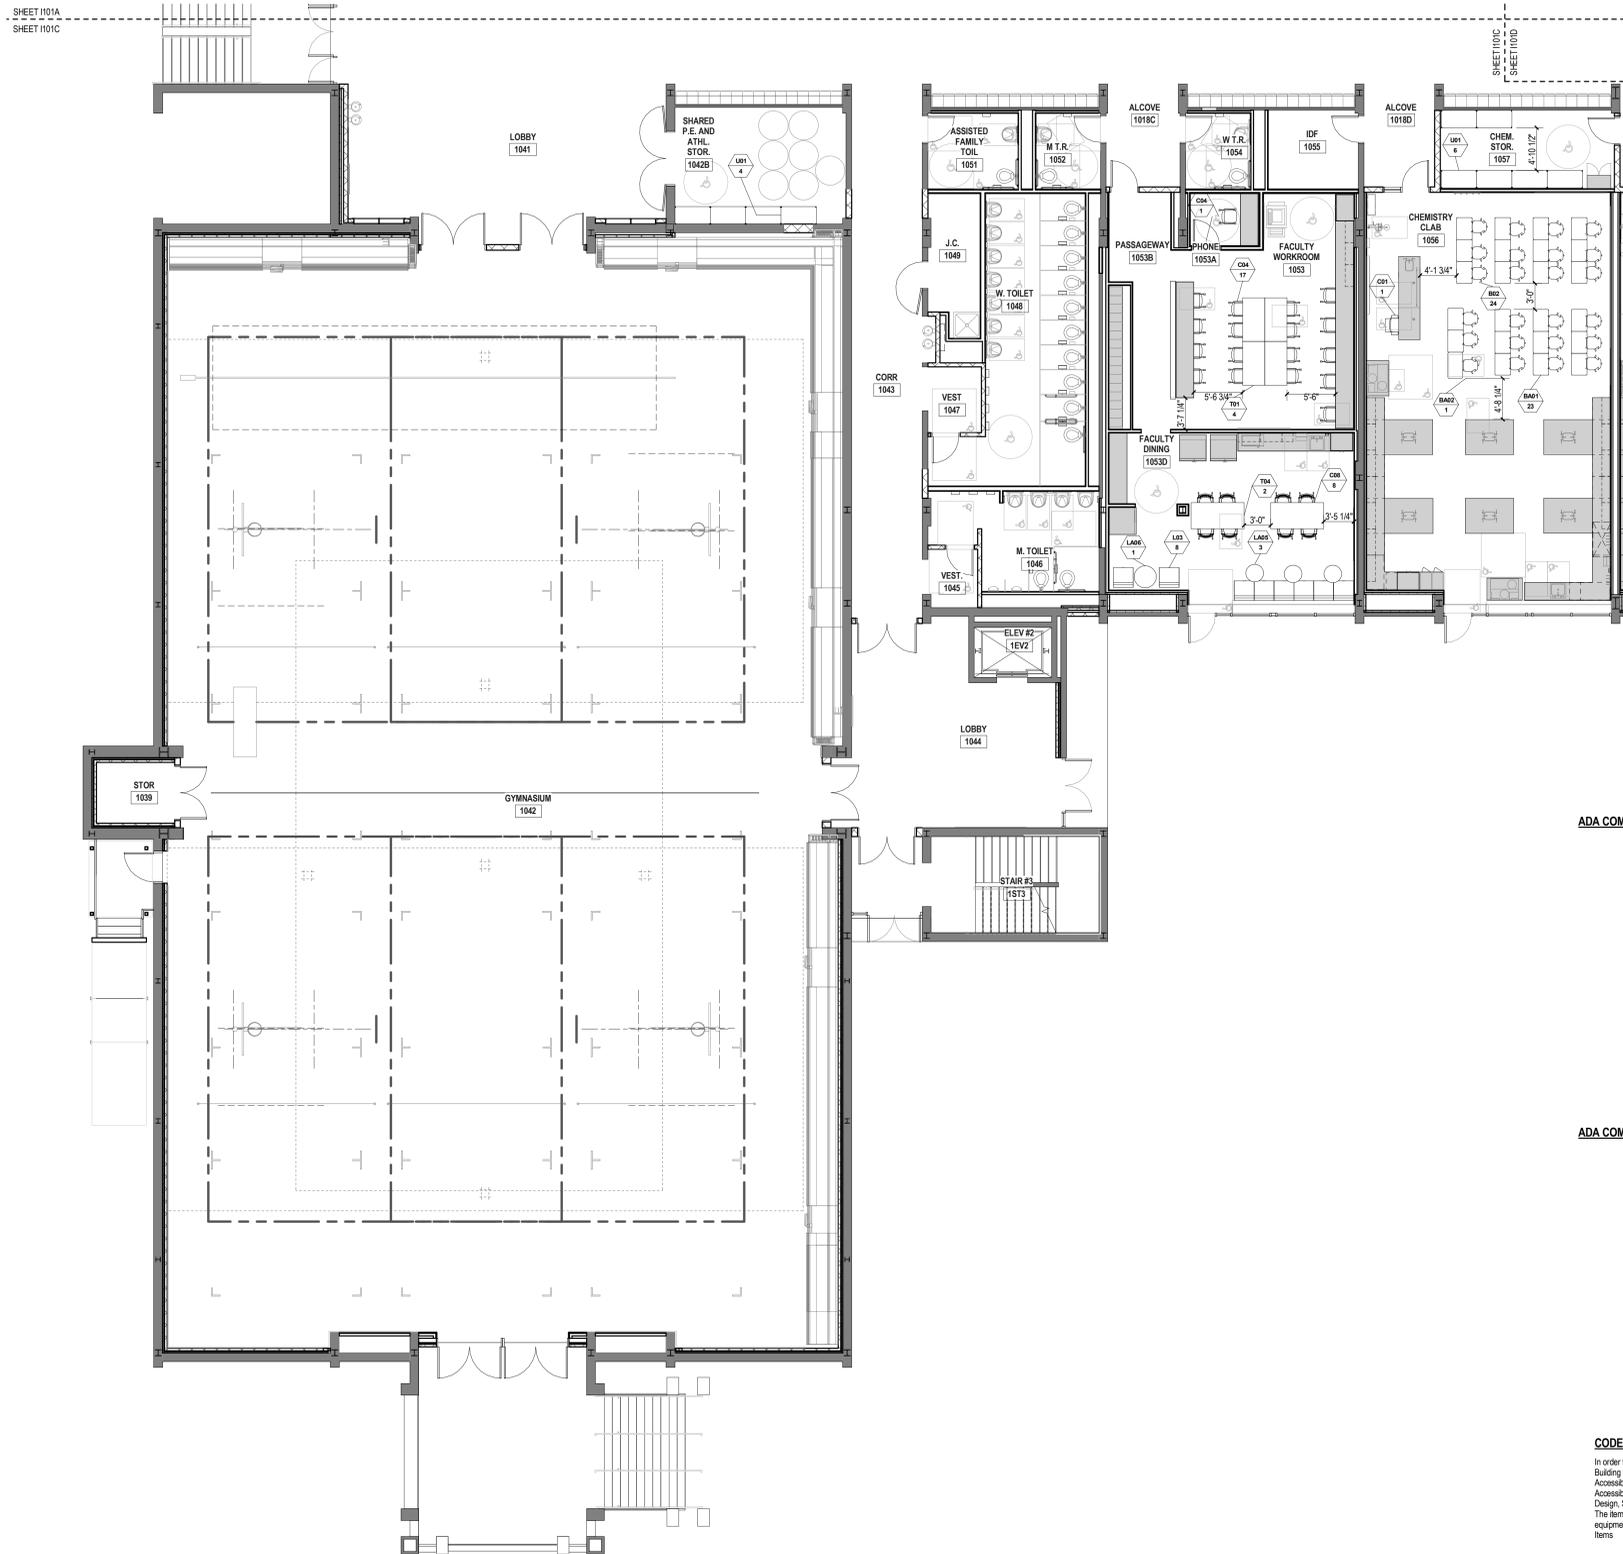

ADA COMPLIANT CLEARANCES FOR ADULTS:

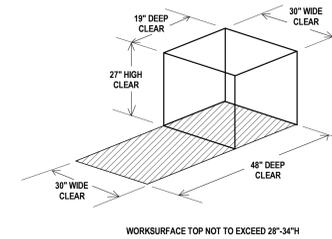

ADA COMPLIANT CLEARANCES FOR CHILDREN:

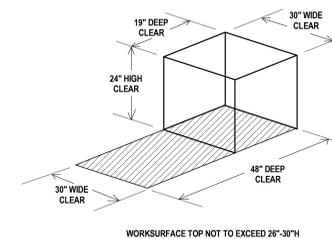

CODE COMPLIANCE NOTE:

In order to meet the needs of persons with disabilities, when applicable all items shall comply with the current Connecticut Basic Building Code including 2003 ICC/ANSI A117.1, Section 504 Rehabilitation Act 1973, including the 2010 ADA Standards for Accessible Design and Section 504 Regulations, and the Americans with Disabilities Act Title II, including the 2010 ADA Standards for Accessible Design and ADA Regulations. Accessible knee and toe clearances shall comply with 2010 ADA Standards for Accessible Design, Section 308. Compliance with the current Connecticut Fire Safety Code and current O.S.H.A. Title 29 labor is also required. The items shall include, but are not limited to, fixtures, furnishings, equipment, workstations (including built-ins), playground equipment, laboratory fume hoods, denroom equipment, welding stations, shop equipment and etc. Secure Attachment of FF&E items.

SECURE ATTACHMENT NOTE:

To ensure proper attachment of Fixtures, Furnishings & Equipment items, including Technology items, where "items" are attached to wall, ceiling, and/or floor, Contractor shall provide information adequate to verify that fixtures, furnishings and equipment attached to wall, ceiling and/or floor are attached securely. Architect's review may be implemented during submittal process. Contractor shall provide studs, hangers, fasteners, safety harnesses, channels, bolts, screws, rods, and etc. to securely attach items to existing structure as required to meet field conditions and meet applicable code.

*REFER TO FURNITURE SCHEDULE BY ROOM ON SHEET I200 FOR COMPLETE LIST OF ALL FF&E ITEMS IN ALL ROOMS

ITEMS SHOWN SHADED ARE PART OF THE CONSTRUCTION PACKAGE (INCLUDING MILLWORK, CASEWORK AND EQUIPMENT) AND ARE FOR REFERENCE ONLY.

1 FIRST FLOOR FURNITURE PLAN - PART C
1/8" = 1'-0"

Drawn AH	
Checked Checker	




NONNEWAUG HIGH SCHOOL

PHASE 3 of 3
FIXTURES, FURNISHINGS & EQUIPMENT

5 MINORTOWN RD
WOODBURY, CT 06798

STATE PROJECT NO. 214-0093 RN
STATE PROJECT NO. 214-0096 BE/A/CV

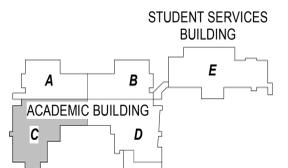

KEYPLAN

Number	Date	Issued For
11/15/2017		ISSUED FOR BID

FIRST FLOOR FURNITURE PLAN - PART C

Date 01-12-2018	Drawing Number 1101C
Scale As indicated	Proj. Number 15232.00


A

B


C

D


E

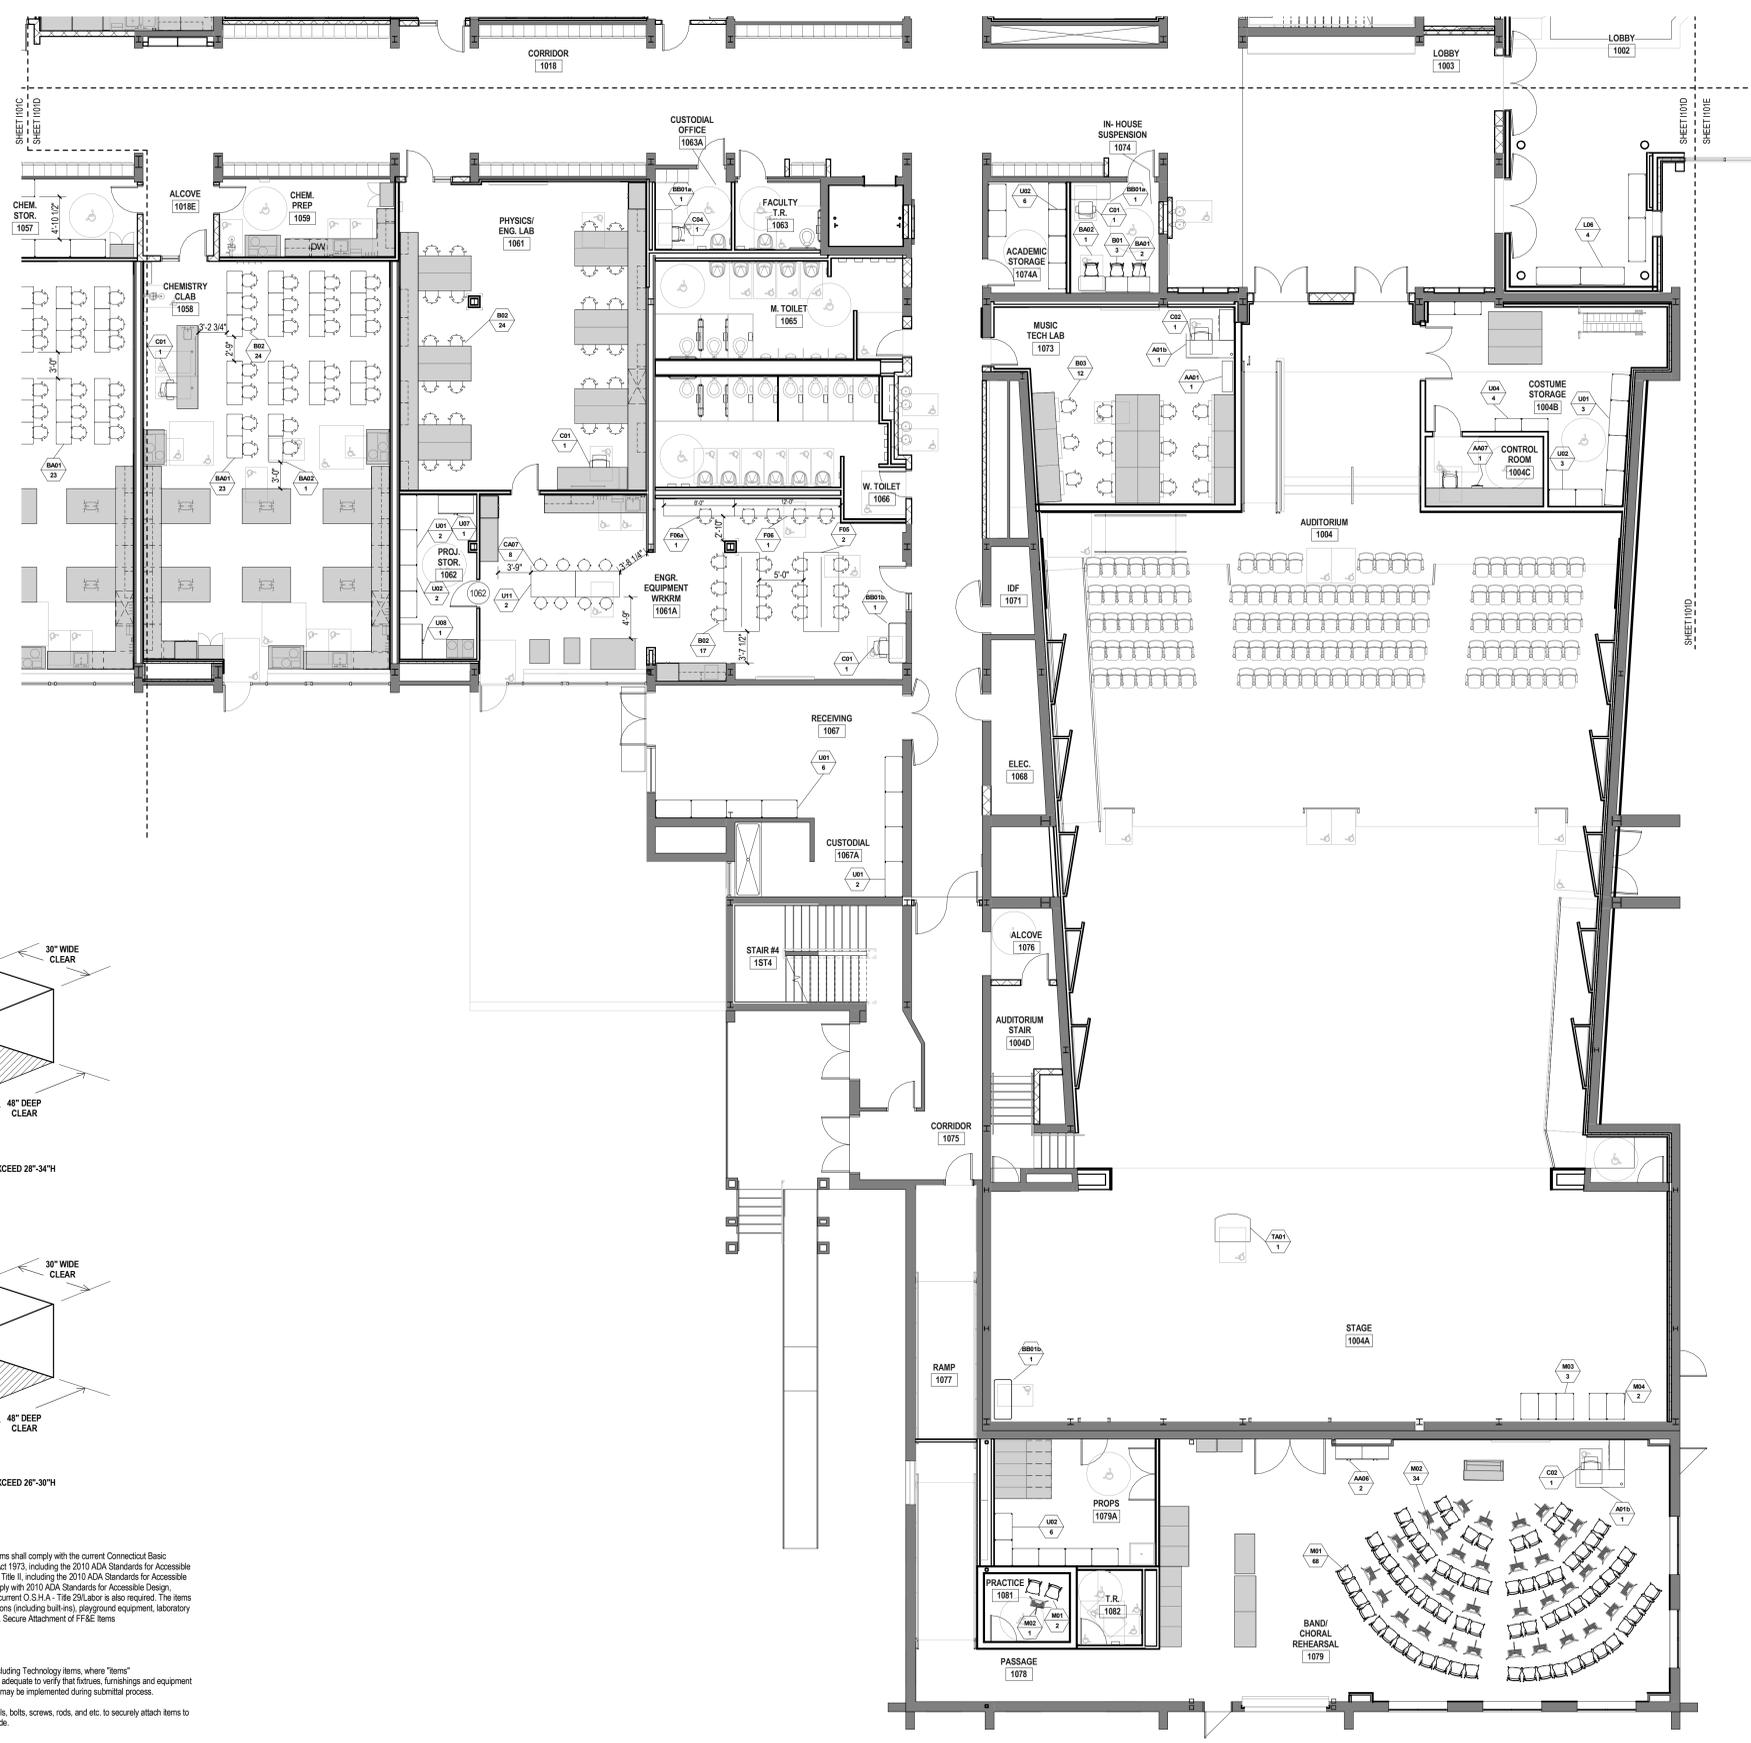

ADA COMPLIANT CLEARANCES FOR ADULTS:

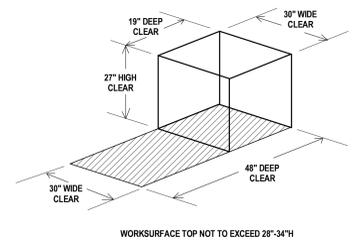

ADA COMPLIANT CLEARANCES FOR CHILDREN:

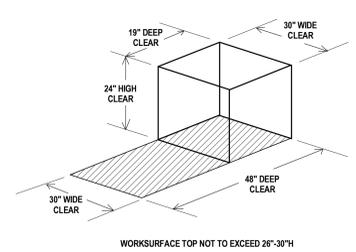

CODE COMPLIANCE NOTE:

In order to meet the needs of persons with disabilities, when applicable all items shall comply with the current Connecticut Basic Building Code including 2003 ICC/ANSI A117.1, Section 504 Rehabilitation Act 1973, including the 2010 ADA Standards for Accessible Design and Section 504 Regulations, and the Americans with Disabilities Act Title II, including the 2010 ADA Standards for Accessible Design and ADA Regulations. Accessible knee and toe clearances shall comply with 2010 ADA Standards for Accessible Design, Section 306. Compliance with the current Connecticut Fire Safety Code and current O.S.H.A. Title 29 Labor is also required. The items shall include, but are not limited to, fixtures, furnishings, equipment, workstations (including built-ins), playground equipment, laboratory fume hoods, darkroom equipment, welding stations, shop equipment and etc. Secure Attachment of FF&E Items

SECURE ATTACHMENT NOTE:

To ensure proper attachment of Fixtures, Furnishings & Equipment items, including Technology items, where "Items" are attached to wall, ceiling, and/or floor, Contractor shall provide information adequate to verify that fixtures, furnishings and equipment attached to wall, ceiling and/or floor are attached securely. Architects review may be implemented during submittal process.

Contractor shall provide struts, hangers, fasteners, safety harnesses, channels, bolts, screws, rods, and etc. to securely attach items to existing structure as required to meet field conditions and meet applicable code.

*REFER TO FURNITURE SCHEDULE BY ROOM ON SHEET I200 FOR COMPLETE LIST OF ALL FF&E ITEMS IN ALL ROOMS

ITEMS SHOWN SHADED ARE PART OF THE CONSTRUCTION PACKAGE (INCLUDING MILLWORK, CASEWORK AND EQUIPMENT) AND ARE FOR REFERENCE ONLY.

1 FIRST FLOOR FURNITURE PLAN - PART D
1/8" = 1'-0"

Drawn	AH
Checked	
Checker	




NONNEWAUG HIGH SCHOOL

PHASE 3 of 3
FIXTURES, FURNISHINGS & EQUIPMENT

5 MINORTOWN RD
WOODBURY, CT 06798

STATE PROJECT NO. 214-0093 RN
STATE PROJECT NO. 214-0096 BE/A/CV

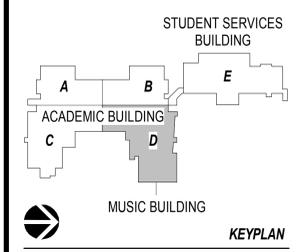

Number	Date	Issued For
	11/15/2017	ISSUED FOR BID

FIRST FLOOR FURNITURE PLAN - PART D

Date	01-12-2018	Drawing Number	I101D
Scale	As indicated		
Proj. Number	15232.00		

© 2017 The SLAM Collaborative, Inc. C:\Revit\Projects\Nonnewaug_A_SLAM_02016_Hastings@slamcoll.com.rvt 4/22/2018 4:07:19 PM

Drawn AH	
Checked Checker	




NONNEWAUG HIGH SCHOOL

PHASE 3 of 3
FIXTURES, FURNISHINGS & EQUIPMENT

5 MINORTOWN RD
WOODBURY, CT 06798


STATE PROJECT NO. 214-0093 RN
STATE PROJECT NO. 214-0096 BE/A/CV

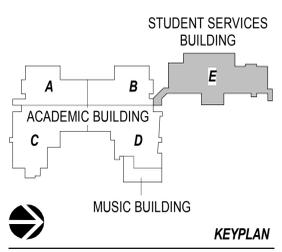

Number	Date	Issued For
11/15/2017	ISSUED FOR BID	


FIRST FLOOR FURNITURE PLAN - PART E

Date 01-12-2018	Drawing Number 1101E
Scale As indicated	Proj. Number 15232.00

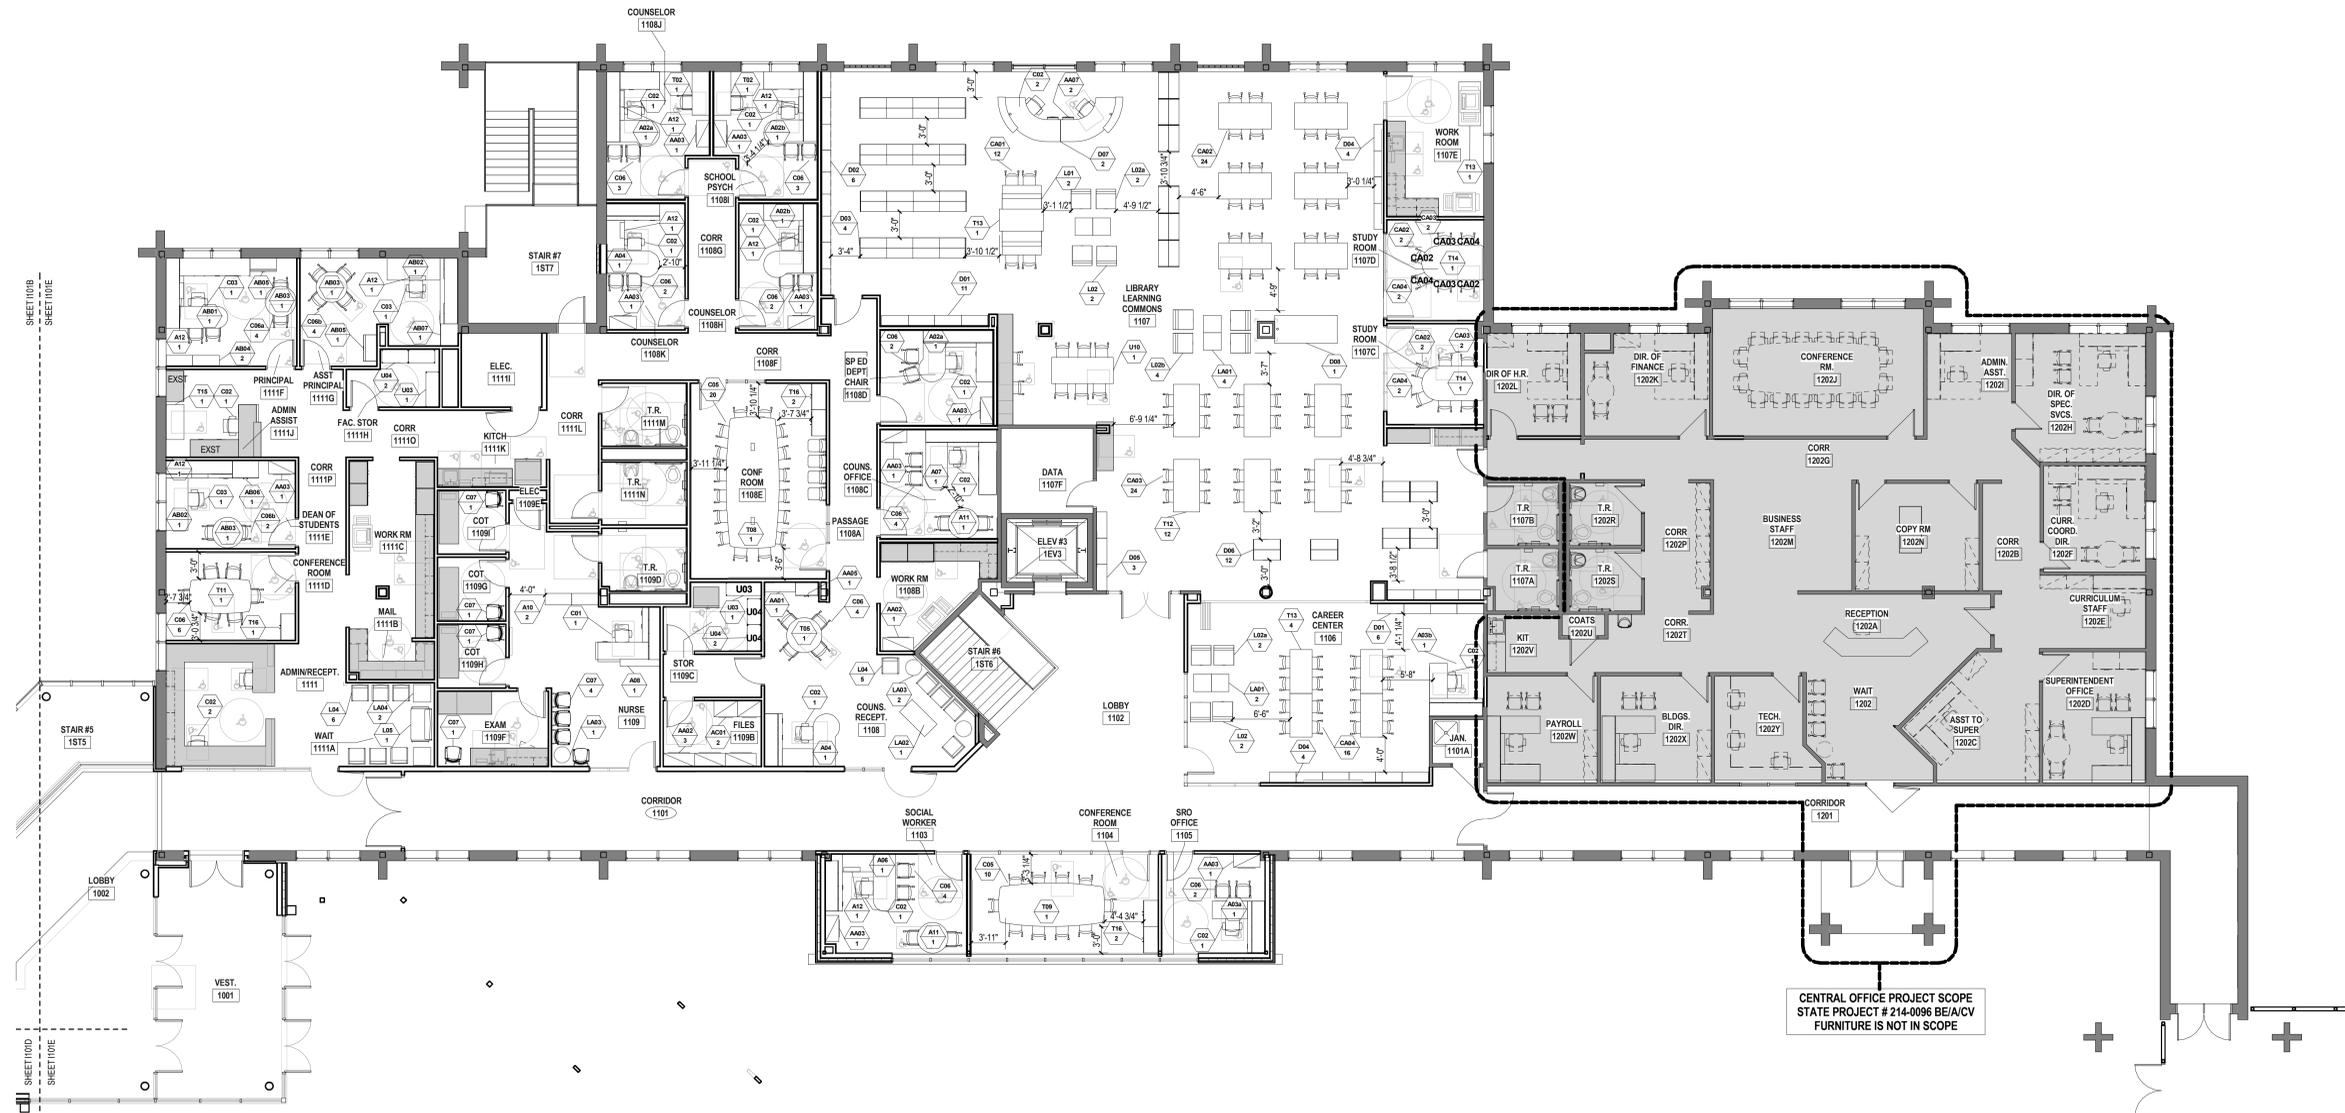


1 FIRST FLOOR FURNITURE PLAN - PART E
1/8" = 1'-0"

ADA COMPLIANT CLEARANCES FOR ADULTS:

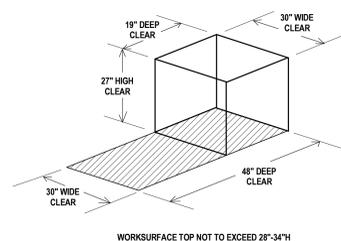

ADA COMPLIANT CLEARANCES FOR CHILDREN:

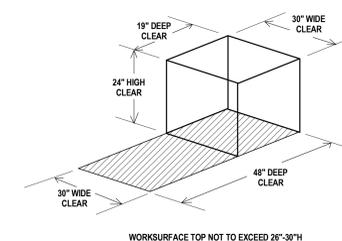

CODE COMPLIANCE NOTE:

In order to meet the needs of persons with disabilities, when applicable all items shall comply with the current Connecticut Basic Building Code including 2003 ICC(ANSI) A117.1, Section 504 Rehabilitation Act 1973, including the 2010 ADA Standards for Accessible Design and Section 504 Regulations, and the Americans with Disabilities Act Title II, including the 2010 ADA Standards for Accessible Design and ADA Regulations. Accessible knee and toe clearances shall comply with 2010 ADA Standards for Accessible Design, Section 305. Compliance with the current Connecticut Fire Safety Code and current O.S.H.A. - Title 29 Labor is also required. The items shall include, but are not limited to, fixtures, furnishings, equipment, workstations (including built-ins), playground equipment, laboratory fume hoods, darkroom equipment, welding stations, shop equipment and etc. Secure Attachment of FF&E Items

SECURE ATTACHMENT NOTE:

To ensure proper attachment of Fixtures, Furnishings & Equipment Items, including Technology Items, where "Items" are attached to wall, ceiling and/or floor. Contractor shall provide information adequate to verify that fixtures, furnishings and equipment attached to wall, ceiling and/or floor are attached securely. Architect's review may be implemented during submittal process. Contractor shall provide struts, hangers, fasteners, safety harnesses, channels, bolts, screws, rods, and etc. to securely attach items to existing structure as required to meet field conditions and meet applicable code.

*REFER TO FURNITURE SCHEDULE BY ROOM ON SHEET 1200 FOR COMPLETE LIST OF ALL FF&E ITEMS IN ALL ROOMS
ITEMS SHOWN SHADED ARE PART OF THE CONSTRUCTION PACKAGE (INCLUDING MILLWORK, CASEWORK, AND EQUIPMENT) AND ARE FOR REFERENCE ONLY.

© 2017 The SLAM Collaborative, Inc. C:\Revit\Projects\Nonnewaug_A_SLAM_202016_Hastings@slamcoll.com.rvt 4/22/2018 4:10:00 PM

Drawn AH	
Checked Checker	

 



NONNEWAUG HIGH SCHOOL

PHASE 3 of 3
FIXTURES, FURNISHINGS & EQUIPMENT

5 MINORTOWN RD
WOODBURY, CT 06798

STATE PROJECT NO. 214-0093 RN
STATE PROJECT NO. 214-0096 BE/A/CV

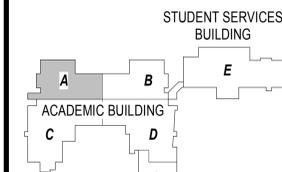


Number	Date	Issued For

Number	Date	Issued For


SECOND FLOOR FURNITURE PLAN - PART A

Date 01-12-2018	Drawing Number I102A
Scale As indicated	Proj. Number 15232.00

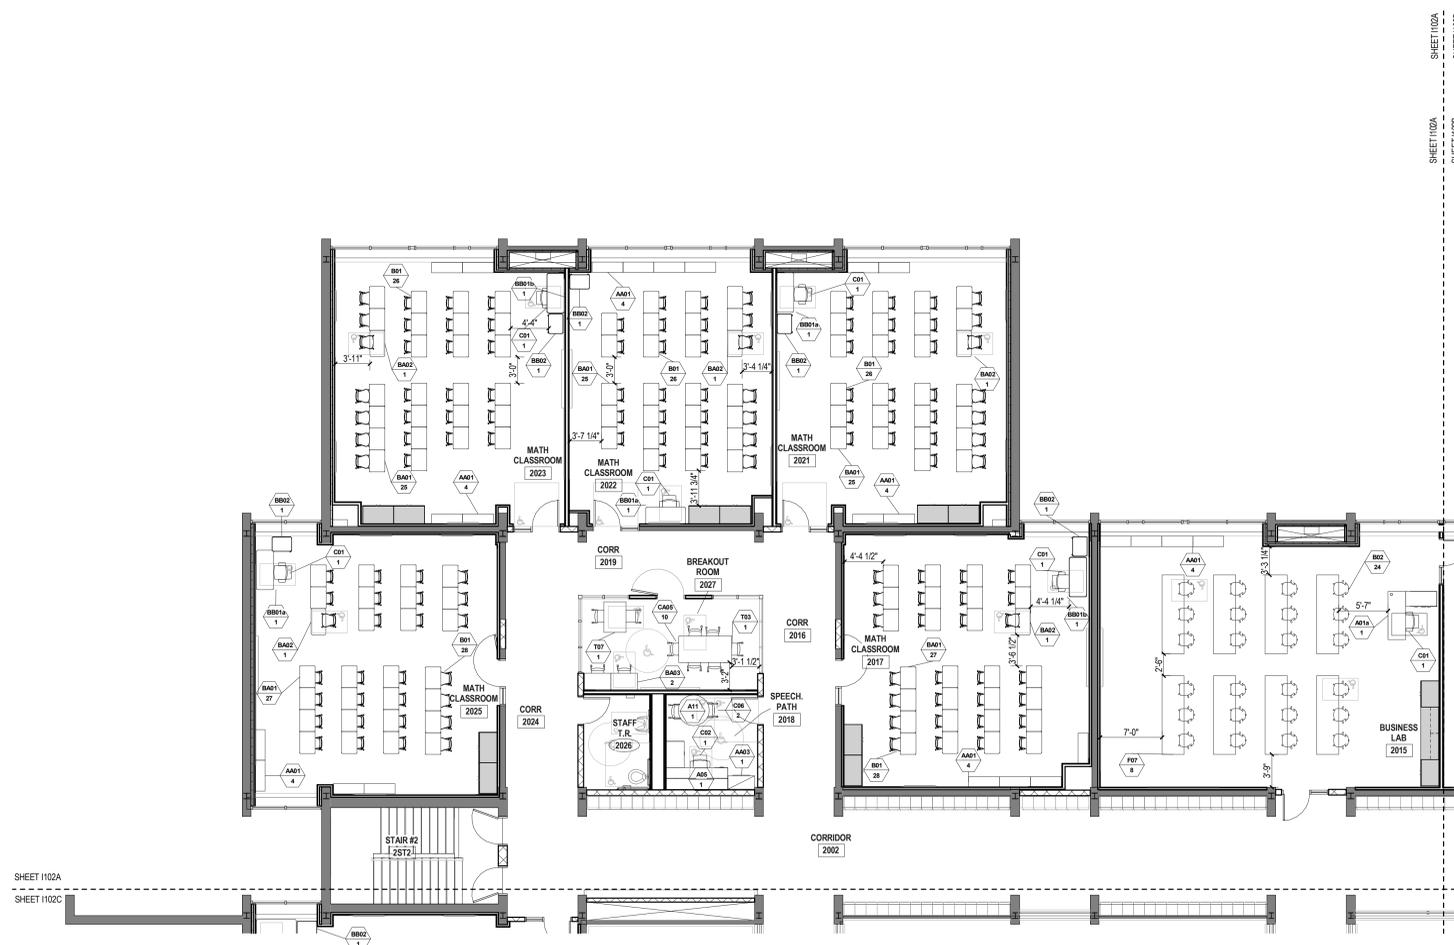


1 SECOND FLOOR FURNITURE PLAN - PART A
1/8" = 1'-0"

ADA COMPLIANT CLEARANCES FOR ADULTS:

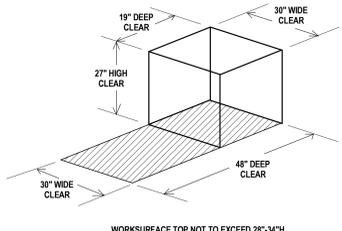

ADA COMPLIANT CLEARANCES FOR CHILDREN:

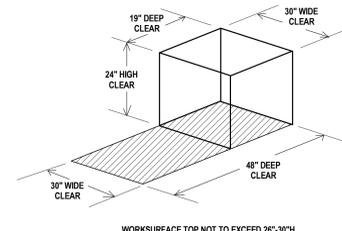

CODE COMPLIANCE NOTE:
In order to meet the needs of persons with disabilities, when applicable all items shall comply with the current Connecticut Basic Building Code including 2003 ICC/ANSI A117.1, Section 504 Rehabilitation Act 1973, including the 2010 ADA Standards for Accessible Design and Section 504 Regulations, and the Americans with Disabilities Act Title II, including the 2010 ADA Standards for Accessible Design and ADA Regulations. Accessible knee and toe clearances shall comply with 2010 ADA Standards for Accessible Design, Section 308. Compliance with the current Connecticut Fire Safety Code and current O.S.H.A. - Title 29 Labor is also required. The items shall include, but are not limited to, fixtures, furnishings, equipment, workstations (including built-ins), playground equipment, laboratory fume hoods, denroom equipment, welding stations, shop equipment and etc. Secure Attachment of FF&E Items

SECURE ATTACHMENT NOTE:
To ensure proper attachment of Fixtures, Furnishings & Equipment items, including Technology items, where "Items" are attached to wall, ceiling, and/or floor, Contractor shall provide information adequate to verify that fixtures, furnishings and equipment attached to wall, ceiling and/or floor are attached securely. Architect's review may be implemented during submittal process.

Contractor shall provide struts, hangers, fasteners, safety harnesses, channels, bolts, screws, rods, and etc. to securely attach items to existing structure as required to meet field conditions and meet applicable codes.

*REFER TO FURNITURE SCHEDULE BY ROOM ON SHEET I200 FOR COMPLETE LIST OF ALL FF&E ITEMS IN ALL ROOMS. ITEMS SHOWN SHADED ARE PART OF THE CONSTRUCTION PACKAGE (INCLUDING MILLWORK, CASEWORK, AND EQUIPMENT) AND ARE FOR REFERENCE ONLY.

C:\Revit\Projects\Nonnewaug_A_SLAM_I2016_Hastings@slamcoll.com.rvt 1/23/2018 3:15:44 PM


A

B

C


D

E

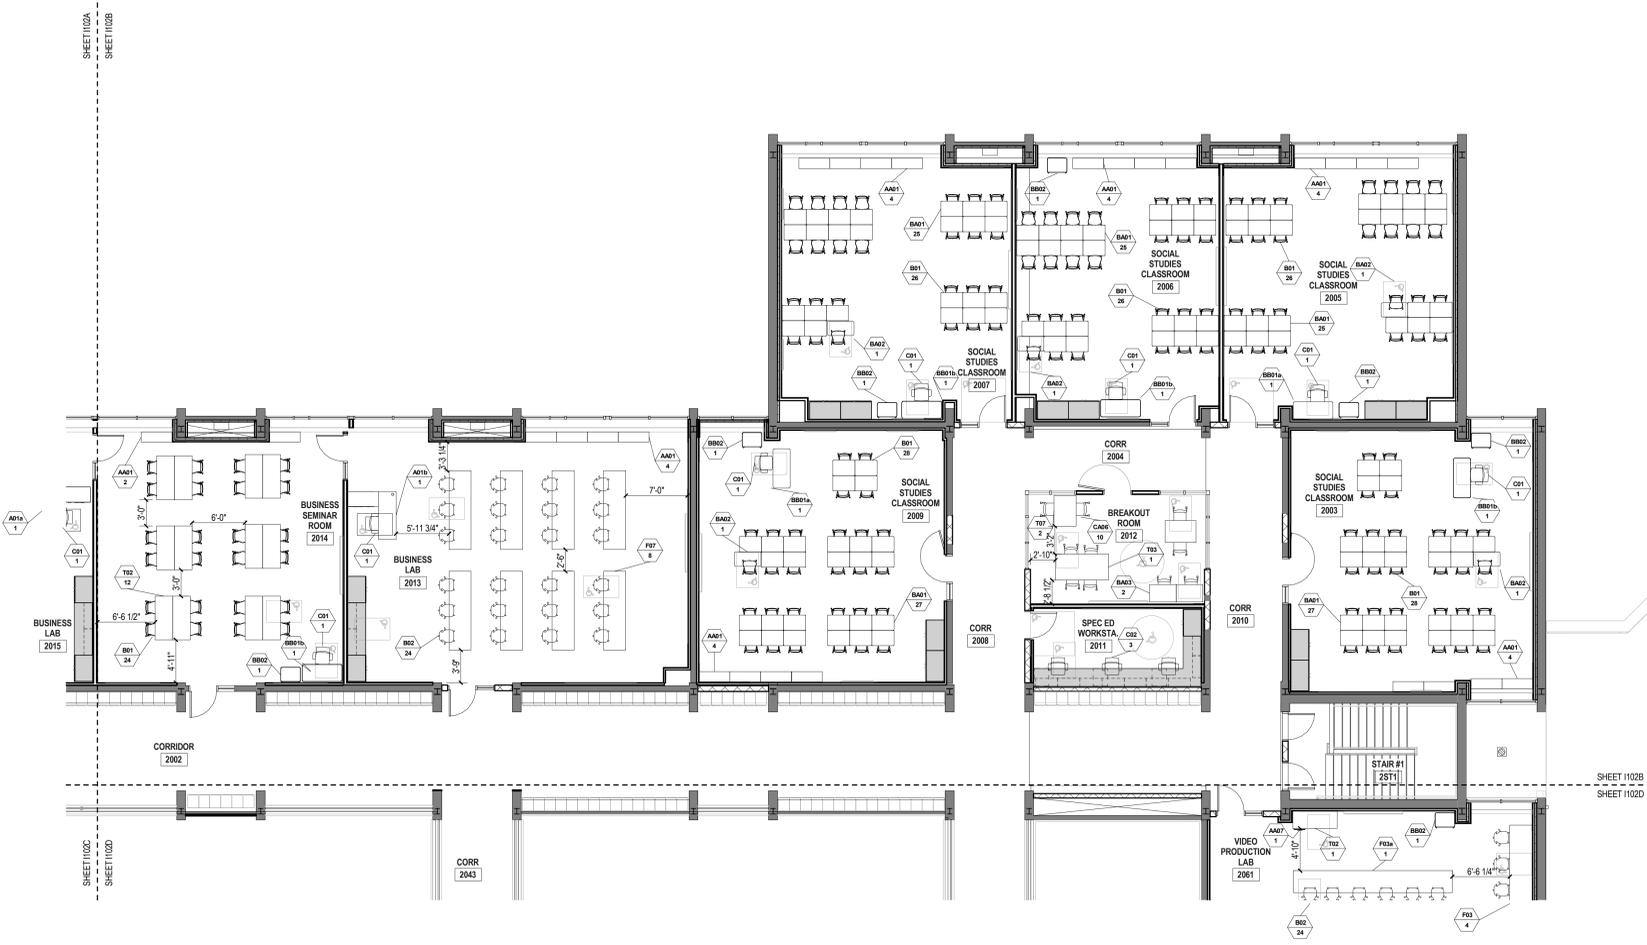


1 SECOND FLOOR FURNITURE PLAN - PART B
1/8" = 1'-0"

ADA COMPLIANT CLEARANCES FOR ADULTS:

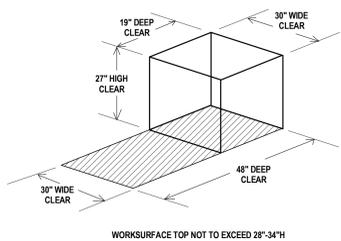

ADA COMPLIANT CLEARANCES FOR CHILDREN:

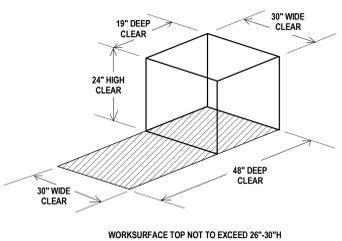

*REFER TO FURNITURE SCHEDULE BY ROOM ON SHEET I200 FOR COMPLETE LIST OF ALL FF&E ITEMS IN ALL ROOMS
ITEMS SHOWN SHADED ARE PART OF THE CONSTRUCTION PACKAGE (INCLUDING MILLWORK, CASEWORK, AND EQUIPMENT) AND ARE FOR REFERENCE ONLY.

CODE COMPLIANCE NOTE:

In order to meet the needs of persons with disabilities, when applicable all items shall comply with the current Connecticut Basic Building Code including 2003 ICC/ANSI A117.1, Section 044 Rehabilitation Act 1973, including the 2010 ADA Standards for Accessible Design and Section 504 Regulations, and the Americans with Disabilities Act Title II, including the 2010 ADA Standards for Accessible Design and ADA Regulations. Accessible knee and toe clearances shall comply with 2010 ADA Standards for Accessible Design, Section 306. Compliance with the current Connecticut Fire Safety Code and current O.S.H.A. - Title 29 Labor is also required. The items shall include, but are not limited to, fixtures, furnishings, equipment, workstations (including built-ins), playground equipment, laboratory fume hoods, classroom equipment, welding stations, shop equipment and etc. Secure Attachment of FF&E Items

SECURE ATTACHMENT NOTE:

To ensure proper attachment of Fixtures, Furnishings & Equipment items, including Technology Items, where "Items" are attached to wall, ceiling, and/or floor, Contractor shall provide information adequate to verify that fixtures, furnishings and equipment attached to wall, ceiling and/or floor are attached securely. Architect's review may be implemented during submittal process. Contractor shall provide struts, hangers, fasteners, safety harnesses, channels, bolts, screws, rods, and etc. to securely attach items to existing structure as required to meet field conditions and meet applicable code.

Drawn AH	
Checked Checker	




NONNEWAUG HIGH SCHOOL

PHASE 3 of 3
FIXTURES, FURNISHINGS & EQUIPMENT

5 MINORTOWN RD
WOODBURY, CT 06798

STATE PROJECT NO. 214-0093 RN
STATE PROJECT NO. 214-0096 BE/A/CV

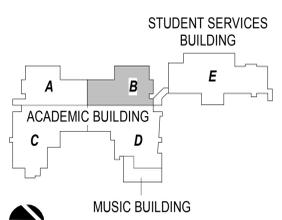

KEYPLAN

Number	Date	Issued For

SECOND FLOOR FURNITURE PLAN - PART B

Date 01-12-2018	Drawing Number I102B
Scale As indicated	Proj. Number 15232.00

© 2018 The SLAM Collaborative, Inc. C:\RevitProjects\Nonnewaug_A_SLAM_I2018_11\102B_1102B.dwg 1/23/2018 3:16:40 PM

A

B


C

D


E



ADA COMPLIANT CLEARANCES FOR ADULTS:

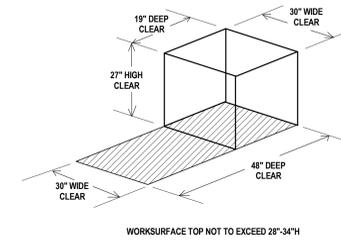

ADA COMPLIANT CLEARANCES FOR CHILDREN:

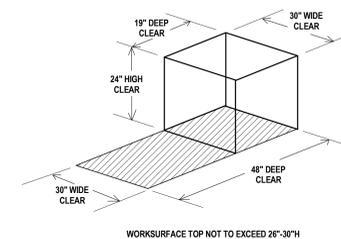

CODE COMPLIANCE NOTE:

In order to meet the needs of persons with disabilities, when applicable all items shall comply with the current Connecticut Basic Building Code including 2003 ICC/ANSI A117.1, Section 504 Rehabilitation Act 1973, including the 2010 ADA Standards for Accessible Design and Section 504 Regulations, and the Americans with Disabilities Act Title II, including the 2010 ADA Standards for Accessible Design and ADA Regulations. Accessible lines and base clearances shall comply with 2010 ADA Standards for Accessible Design, Section 306. Compliance with the current Connecticut Fire Safety Code and current O.S.H.A. - Title 29 Labor is also required. The items shall include, but are not limited to, fixtures, furnishings, equipment, workstations (including built-ins), playground equipment, laboratory fume hoods, darkroom equipment, welding stations, shop equipment and etc. Secure Attachment of FF&E items.

SECURE ATTACHMENT NOTE:

To ensure proper attachment of Fixtures, Furnishings & Equipment items, including Technology items, where "Items" are attached to wall, ceiling, and/or floor. Contractor shall provide information adequate to verify that fixtures, furnishings and equipment attached to wall, ceiling and/or floor are attached securely. Architect's review may be implemented during submittal process.

Contractor shall provide struts, hangers, fasteners, safety harnesses, channels, bolts, screws, rods, and etc. to securely attach items to existing structure as required to meet field conditions and meet applicable code.

*REFER TO FURNITURE SCHEDULE BY ROOM ON SHEET I200 FOR COMPLETE LIST OF ALL FF&E ITEMS IN ALL ROOMS

ITEMS SHOWN SHADED ARE PART OF THE CONSTRUCTION PACKAGE (INCLUDING MILLWORK, CASEWORK AND EQUIPMENT) AND ARE FOR REFERENCE ONLY.

1 SECOND FLOOR PLAN
1/8" = 1'-0"

Drawn
AH
Checked
Checker




NONNEWAUG HIGH SCHOOL

PHASE 3 of 3
FIXTURES, FURNISHINGS & EQUIPMENT

5 MINORTOWN RD
WOODBURY, CT 06798

STATE PROJECT NO. 214-0093 RN
STATE PROJECT NO. 214-0096 BE/A/CV

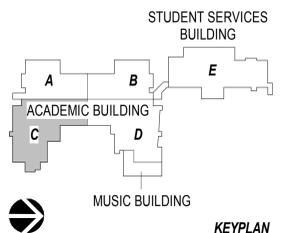

KEYPLAN

Number	Date	Issued For

SECOND FLOOR FURNITURE PLAN - PART C

Date: 01-12-2018
Drawing Number: **I102C**
Scale: As indicated
Proj. Number: 15232.00


A

B


C

D


E

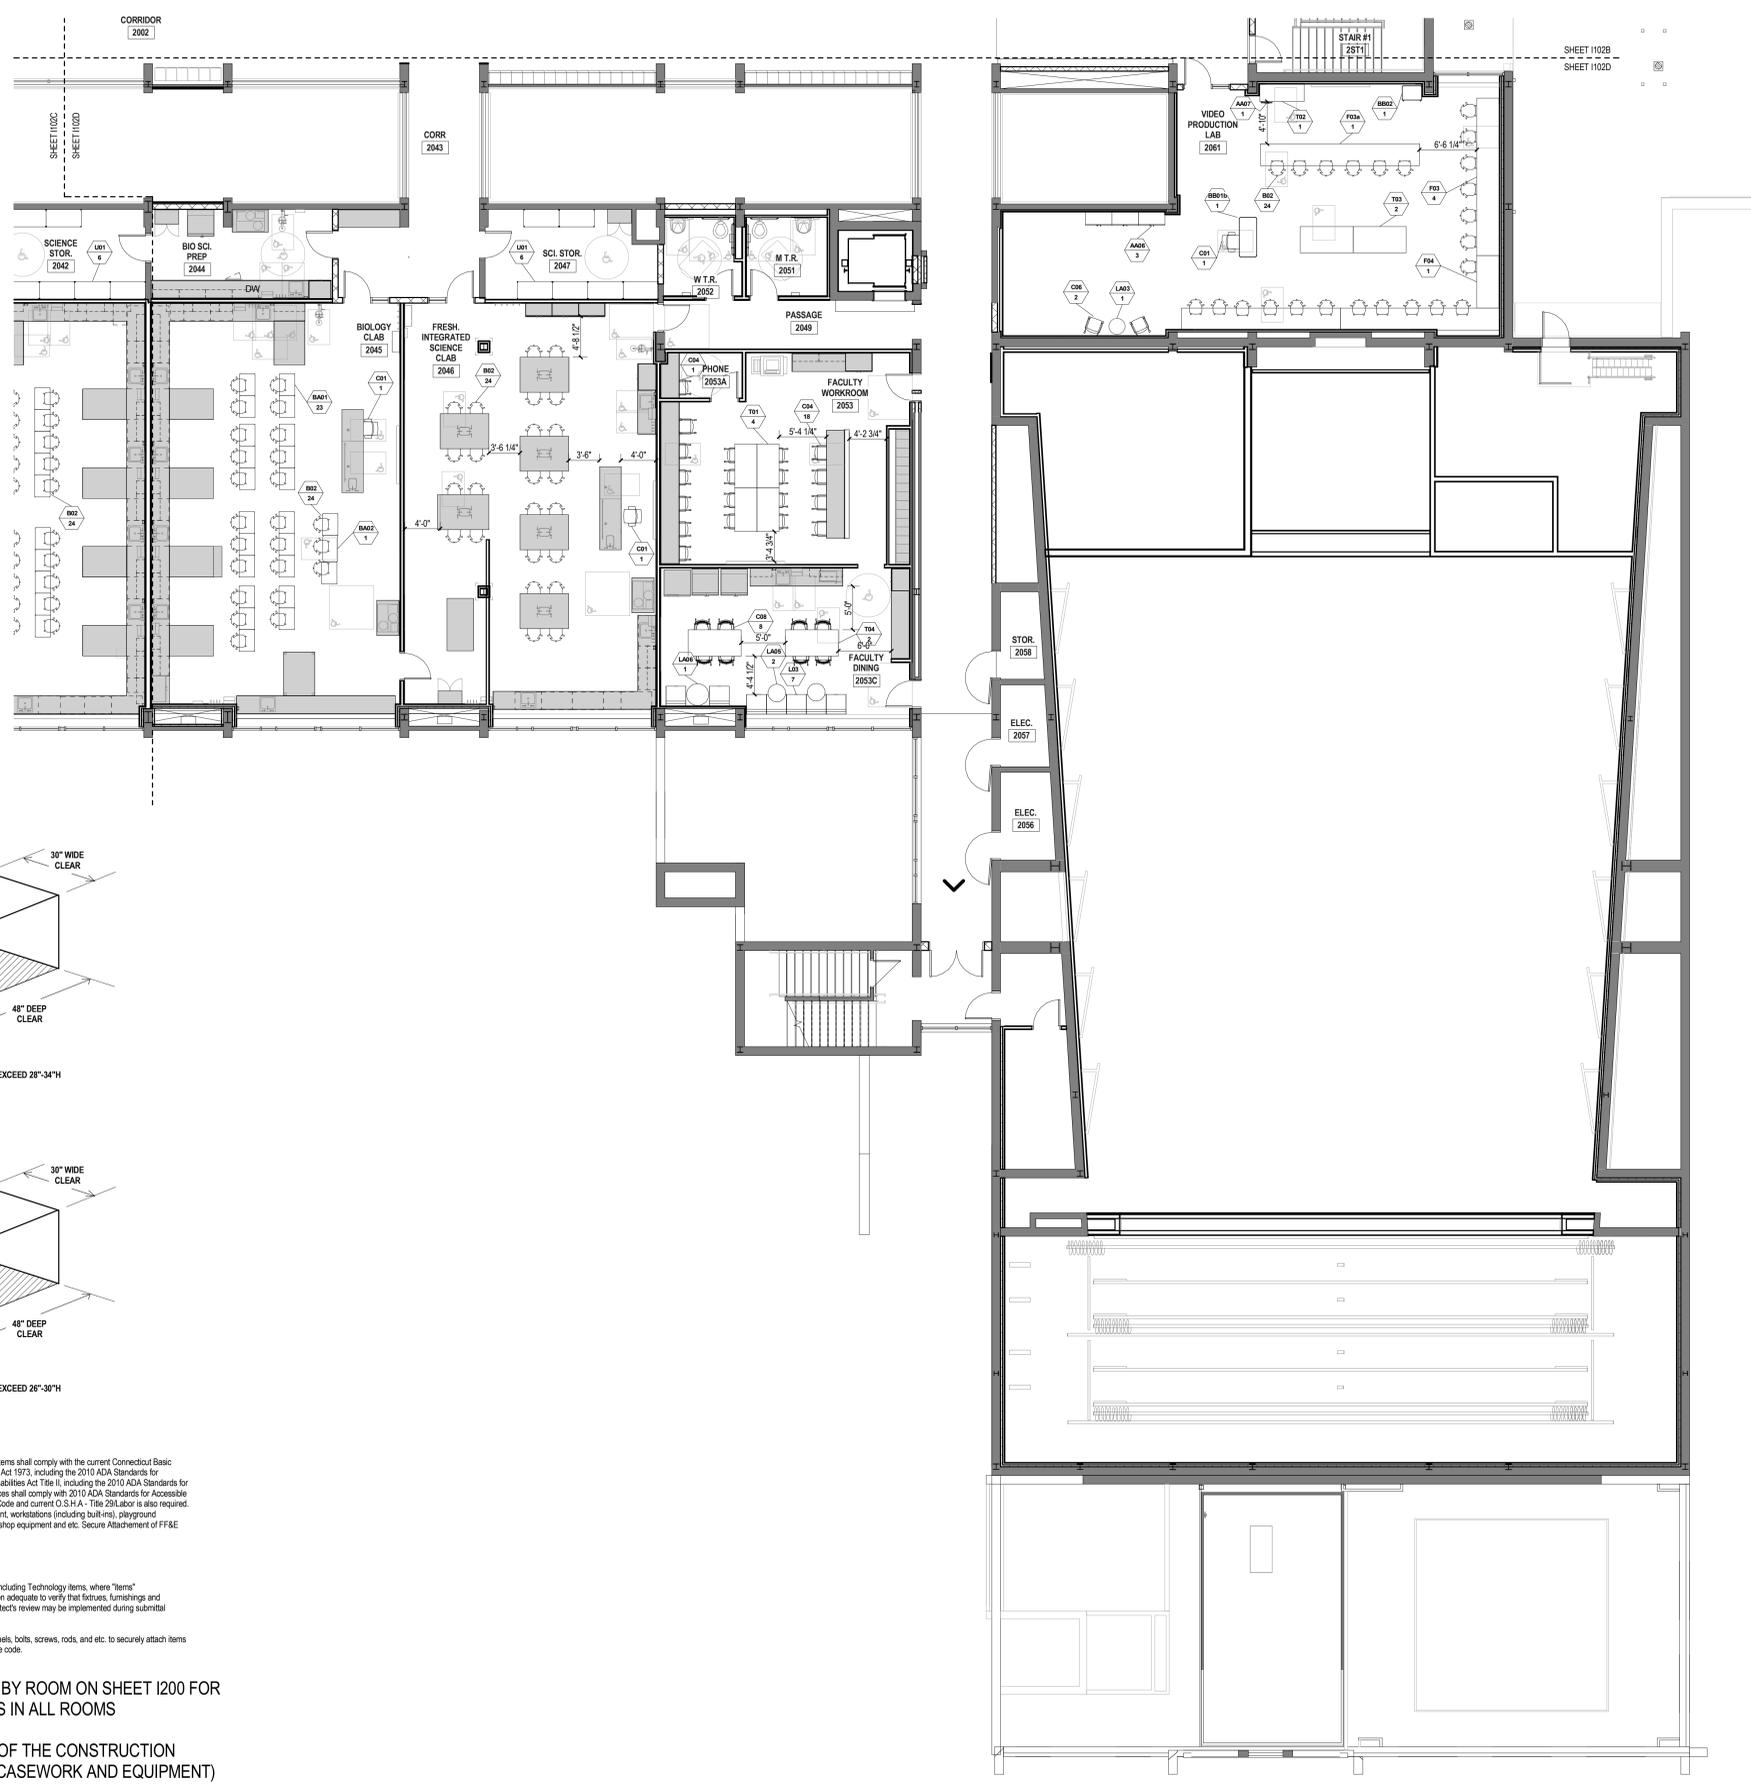

ADA COMPLIANT CLEARANCES FOR ADULTS:

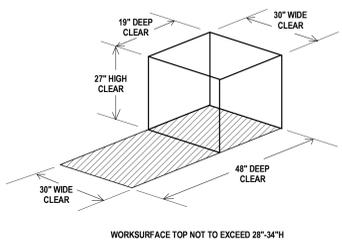

ADA COMPLIANT CLEARANCES FOR CHILDREN:

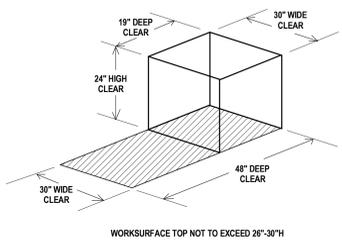

CODE COMPLIANCE NOTE:

In order to meet the needs of persons with disabilities, when applicable all items shall comply with the current Connecticut Basic Building Code including 2003 ICC/ANSI A117.1, Section 504 Rehabilitation Act 1973, including the 2010 ADA Standards for Accessible Design and Section 504 Regulations, and the Americans with Disabilities Act Title II, including the 2010 ADA Standards for Accessible Design and ADA Regulations. Accessible knee and toe clearances shall comply with 2010 ADA Standards for Accessible Design, Section 308. Compliance with the current Connecticut Fire Safety Code and current O.S.H.A. - Title 29 labor is also required. The items shall include, but are not limited to, fixtures, furnishings, equipment, workstations (including built-ins), playground equipment, laboratory fume hoods, classroom equipment, welding stations, shop equipment and etc. Secure Attachment of FF&E items.

SECURE ATTACHMENT NOTE:

To ensure proper attachment of Fixtures, Furnishings & Equipment items, including Technology items, where "Items" are attached to wall, ceiling, and/or floor, Contractor shall provide information adequate to verify that fixtures, furnishings and equipment attached to wall, ceiling and/or floor are attached securely. Architect's review may be implemented during submittal process.

Contractor shall provide struts, hangers, fasteners, safety harnesses, channels, bolts, screws, rods, and etc. to securely attach items to existing structure as required to meet field conditions and meet applicable code.

*REFER TO FURNITURE SCHEDULE BY ROOM ON SHEET I200 FOR COMPLETE LIST OF ALL FF&E ITEMS IN ALL ROOMS

ITEMS SHOWN SHADED ARE PART OF THE CONSTRUCTION PACKAGE (INCLUDING MILLWORK, CASEWORK AND EQUIPMENT) AND ARE FOR REFERENCE ONLY.


1 SECOND FLOOR FURNITURE PLAN - PART D
1/8" = 1'-0"

Drawn	AH
Checked	
Checker	



NONNEWAUG HIGH SCHOOL
PHASE 3 of 3
FIXTURES, FURNISHINGS & EQUIPMENT
5 MINORTOWN RD
WOODBURY, CT 06798

STATE PROJECT NO. 214-0093 RN
STATE PROJECT NO. 214-0096 BE/A/CV

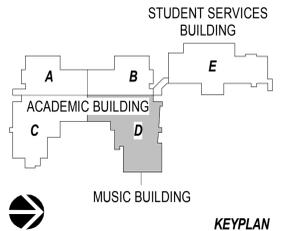

Number	Date	Issued For

SECOND FLOOR FURNITURE PLAN - PART D

Date	01-12-2018	Drawing Number	I102D
Scale	As indicated	Proj. Number	15232.00

© 2018 The SLAM Collaborative, Inc. C:\Revit\Projects\Nonnewaug_A_SLAM_2018_Hastings@slamcoll.com.rvt 1/23/2018 3:17:09 PM

1

2

3

4

5

A


B

C

D


E

FF&E PHASING SCHEDULE	
PHASE 1; TO BE DELIVERED AUGUST 2018	
PHASE 2; TO BE DELIVERED DECEMBER 2018	
PHASE 3; TO BE DELIVERED APRIL 2019	
PHASE 4; TO BE DELIVERED AUGUST 2019	
PHASE 5; TO BE DELIVERED NOVEMBER 2019	

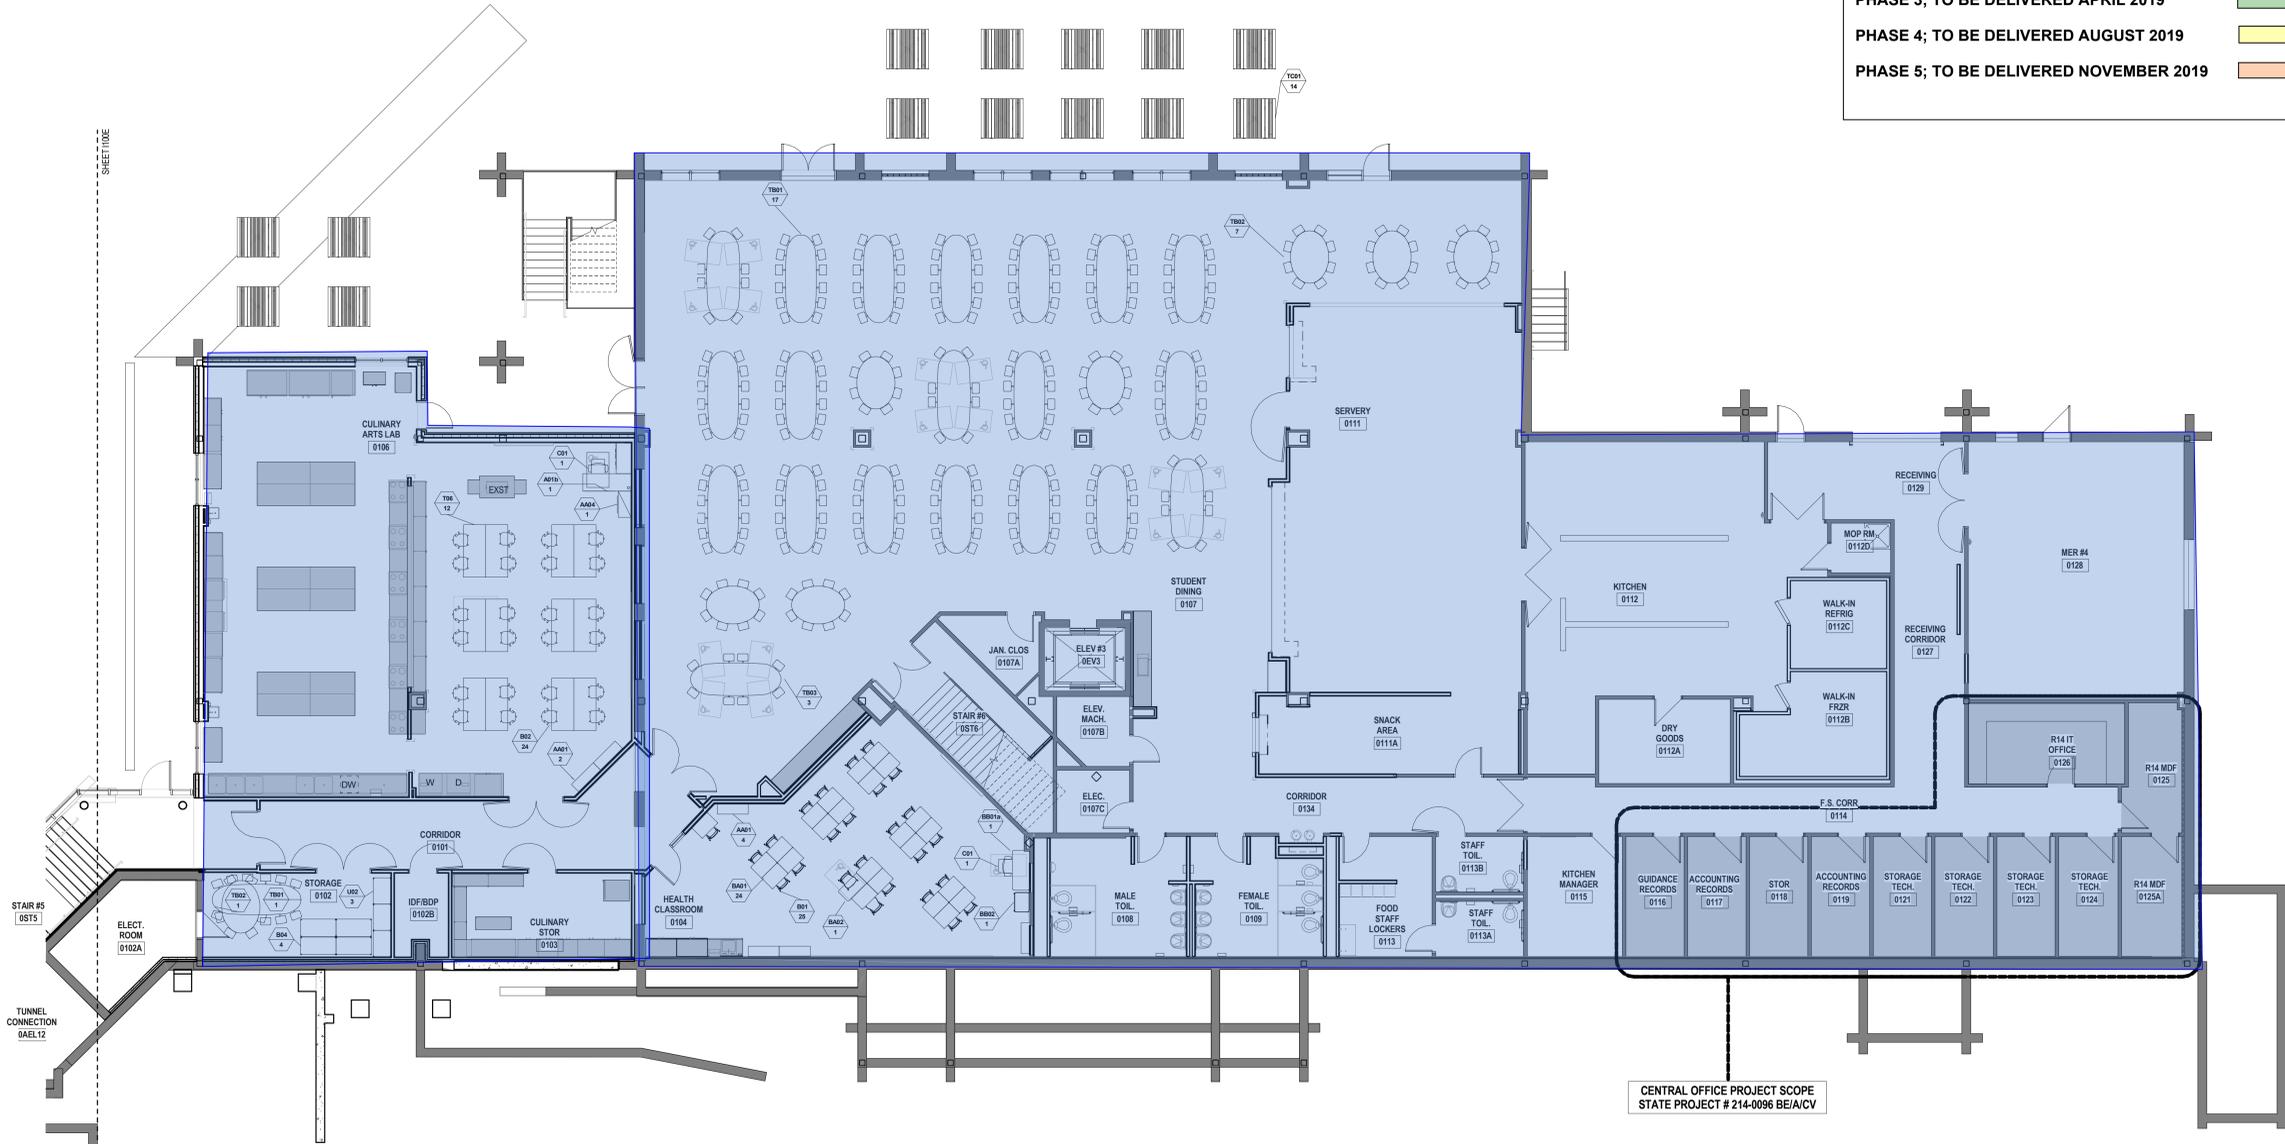


1 LOWER LEVEL FURNITURE PLAN - PART E
1/8" = 1'-0"

ADA COMPLIANT CLEARANCES FOR ADULTS:

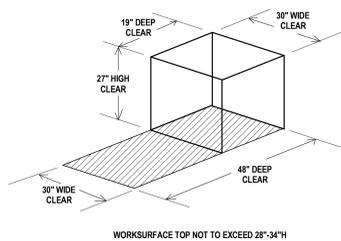

ADA COMPLIANT CLEARANCES FOR CHILDREN:

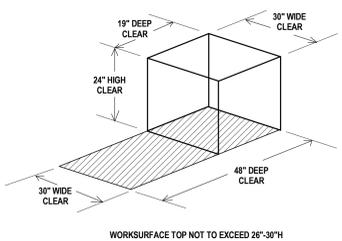

CODE COMPLIANCE NOTE:

In order to meet the needs of persons with disabilities, when applicable all items shall comply with the current Connecticut Basic Building Code including 2003 ICC/ANSI A117.1, Section 044 Rehabilitation Act 1973, including the 2010 ADA Standards for Accessible Design and Section 044 Regulations, and the Americans with Disabilities Act Title II, including the 2010 ADA Standards for Accessible Design and ADA Regulations. Accessible knee and toe clearances shall comply with 2010 ADA Standards for Accessible Design, Section 306. Compliance with the current Connecticut Fire Safety Code and current O.S.H.A. - Title 29 Labor is also required. The items shall include, but are not limited to, fixtures, furnishings, equipment, workstations (including built-ins), playground equipment, laboratory furniture, classroom equipment, welding stations, shop equipment and etc. Secure Attachment of FF&E Items

SECURE ATTACHMENT NOTE:

To ensure proper attachment of Fixtures, Furnishings & Equipment items, including Technology items, where "Items" are attached to wall, ceiling, and/or floor, Contractor shall provide information adequate to verify that fixtures, furnishings and equipment attached to wall, ceiling and/or floor are attached securely. Architect's review may be implemented during submittal process.

Contractor shall provide struts, hangers, fasteners, safety harnesses, channels, bolts, screws, rods, and etc. to securely attach items to existing structure as required to meet field conditions and meet applicable code.

*REFER TO FURNITURE SCHEDULE BY ROOM ON SHEET I200 FOR COMPLETE LIST OF ALL FF&E ITEMS IN ALL ROOMS
ITEMS SHOWN SHADED ARE PART OF THE CONSTRUCTION PACKAGE (INCLUDING MILLWORK, CASEWORK, AND EQUIPMENT) AND ARE FOR REFERENCE ONLY.

SLAM
The S/L/A/M Collaborative

80 Glastonbury Blvd
Glastonbury, CT 06033-4410
phone 860.657.8077
fax 860.657.3141

www.slamcoll.com


Drawn
AH
Checked
Checker

Region 14 Schools
Inspiring Excellence

NONNEWAUG HIGH SCHOOL
PHASE 3 of 3
FIXTURES, FURNISHINGS & EQUIPMENT

5 MINORTOWN RD
WOODBURY, CT 06798

STATE PROJECT NO. 214-0093 RN
STATE PROJECT NO. 214-0096 BE/A/CV

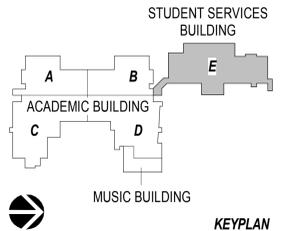

KEYPLAN

Number	Date	Issued For

LOWER LEVEL FURNITURE PLAN - PART E
INSTALLATION PHASING

Date: 01-12-2018
Drawing Number: **I100E**
Scale: As indicated
Proj. Number: 15232.00

© 2019 The SLAM Collaborative, Inc. C:\RevolProjects\Nonnewaug_A_SLAM_02016_Installings@slamcoll.com.rvt 4/2/2018 10:22:59 AM

FF&E PHASING SCHEDULE	
PHASE 1; TO BE DELIVERED AUGUST 2018	
PHASE 2; TO BE DELIVERED DECEMBER 2018	
PHASE 3; TO BE DELIVERED APRIL 2019	
PHASE 4; TO BE DELIVERED AUGUST 2019	
PHASE 5; TO BE DELIVERED NOVEMBER 2019	

Drawn AH	
Checked Checker	

A

B

C

D

E



1 FIRST FLOOR FURNITURE PLAN - PART A
1/8" = 1'-0"




NONNEWAUG HIGH SCHOOL

PHASE 3 of 3
FIXTURES, FURNISHINGS & EQUIPMENT

5 MINORTOWN RD
WOODBURY, CT 06798


STATE PROJECT NO. 214-0093 RN
STATE PROJECT NO. 214-0096 BE/A/CV

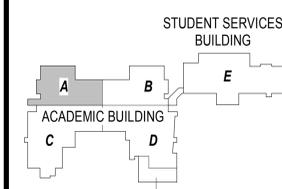


KEYPLAN

Number	Date	Issued For

ADA COMPLIANT CLEARANCES FOR ADULTS:

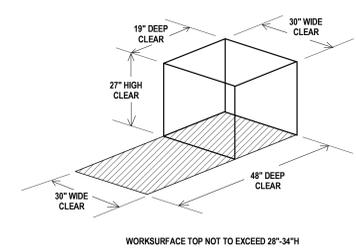

ADA COMPLIANT CLEARANCES FOR CHILDREN:

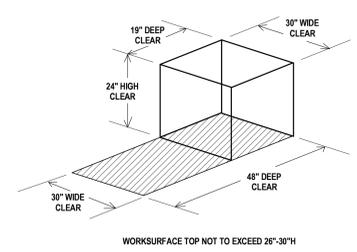

CODE COMPLIANCE NOTE:

In order to meet the needs of persons with disabilities, when applicable all items shall comply with the current Connecticut Basic Building Code including 2003 ICC ANS A117.1, Section 504 Rehabilitation Act 1973, including the 2010 ADA Standards for Accessible Design and Section 504 Regulations, and the Americans with Disabilities Act Title II, including the 2010 ADA Standards for Accessible Design and ADA Regulations. Accessible knee and toe clearances shall comply with 2010 ADA Standards for Accessible Design, Section 306. Compliance with the current Connecticut Fire Safety Code and current O.S.H.A. Title 29 CFR is also required. The items shall include, but are not limited to, fixtures, furnishings, equipment, workstations (including built-ins), playground equipment, laboratory fume hoods, darkroom equipment, welding stations, shop equipment and etc. Secure Attachment of FF&E Items

SECURE ATTACHMENT NOTE:

To ensure proper attachment of Fixtures, Furnishings & Equipment items, including Technology items, where "Items" are attached to wall, ceiling, and/or floor. Contractor shall provide information adequate to verify that fixtures, furnishings and equipment attached to wall, ceiling and/or floor are attached securely. Architect's review may be implemented during submittal process. Contractor shall provide struts, hangers, fasteners, safety harnesses, channels, bolts, screws, rods, and etc. to securely attach items to existing structure as required to meet field conditions and meet applicable code.

*REFER TO FURNITURE SCHEDULE BY ROOM ON SHEET I200 FOR COMPLETE LIST OF ALL FF&E ITEMS IN ALL ROOMS
ITEMS SHOWN SHADED ARE PART OF THE CONSTRUCTION PACKAGE (INCLUDING MILLWORK, CASEWORK, AND EQUIPMENT) AND ARE FOR REFERENCE ONLY.

FIRST FLOOR FURNITURE PLAN - PART A INSTALLATION PHASING

Date	01-12-2018	Drawing Number	I101A
Scale	As indicated	Proj. Number	15232.00

A

B

C

D

E

FF&E PHASING SCHEDULE	
PHASE 1; TO BE DELIVERED AUGUST 2018	
PHASE 2; TO BE DELIVERED DECEMBER 2018	
PHASE 3; TO BE DELIVERED APRIL 2019	
PHASE 4; TO BE DELIVERED AUGUST 2019	
PHASE 5; TO BE DELIVERED NOVEMBER 2019	



1 FIRST FLOOR FURNITURE PLAN - PART B
1/8" = 1'-0"

SLAM
The S/L/A/M Collaborative


80 Glastonbury Blvd
Glastonbury, CT 06033-4410
phone 860.657.8077
fax 860.657.3141
www.slamcoll.com

Drawn AH	
Checked Checker	



NONNEWAUG HIGH SCHOOL
PHASE 3 of 3
FIXTURES, FURNISHINGS & EQUIPMENT
5 MINORTOWN RD
WOODBURY, CT 06798


STATE PROJECT NO. 214-0093 RN
STATE PROJECT NO. 214-0096 BE/A/CV

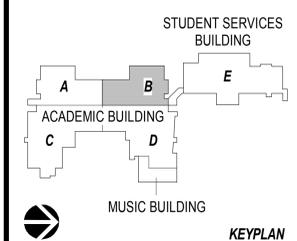


KEYPLAN

Number	Date	Issued For
1	11/15/2017	ISSUED FOR BID

ADA COMPLIANT CLEARANCES FOR ADULTS:

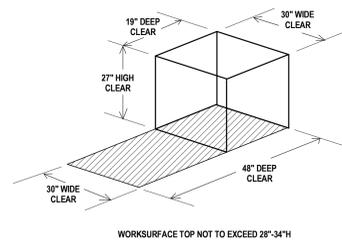

ADA COMPLIANT CLEARANCES FOR CHILDREN:

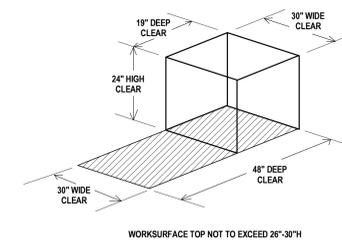

CODE COMPLIANCE NOTE:

In order to meet the needs of persons with disabilities, when applicable all items shall comply with the current Connecticut Basic Building Code including 2003 ICC/ANSI A117.1, Section 504 Rehabilitation Act 1973, including the 2010 ADA Standards for Accessible Design and Section 504 Regulations, and the Americans with Disabilities Act Title II, including the 2010 ADA Standards for Accessible Design and ADA Regulations. Accessible knee and toe clearances shall comply with 2010 ADA Standards for Accessible Design, Section 306. Compliance with the current Connecticut Fire Safety Code and current O.S.H.A. Title 29 Labor is also required. The items shall include, but are not limited to, fixtures, furnishings, equipment, workstations (including built-ins), playground equipment, laboratory fume hoods, classroom equipment, welding stations, shop equipment and etc. Secure Attachment of FF&E Items

SECURE ATTACHMENT NOTE:

To ensure proper attachment of Fixtures, Furnishings & Equipment Items, including Technology items, where "Items" are attached to wall, ceiling, and/or floor. Contractor shall provide information adequate to verify that fixtures, furnishings and equipment attached to wall, ceiling and/or floor are attached securely. Architect's review may be implemented during submittal process.

Contractor shall provide struts, hangers, fasteners, safety harnesses, channels, bolts, screws, rods, and etc. to securely attach items to existing structure as required to meet field conditions and meet applicable code.

*REFER TO FURNITURE SCHEDULE BY ROOM ON SHEET I200 FOR COMPLETE LIST OF ALL FF&E ITEMS IN ALL ROOMS
ITEMS SHOWN SHADED ARE PART OF THE CONSTRUCTION PACKAGE (INCLUDING MILLWORK, CASEWORK, AND EQUIPMENT) AND ARE FOR REFERENCE ONLY.

FIRST FLOOR FURNITURE PLAN - PART B
INSTALLATION PHASING

Date	01-12-2018	Drawing Number	
Scale	As indicated		I101B
Proj. Number	15232.00		

© 2017 The SLAM Collaborative, Inc. C:\RevitProjects\Nonnewaug_A_SLAM_I2018_10-24-27.rvt


A

B

C



D

E

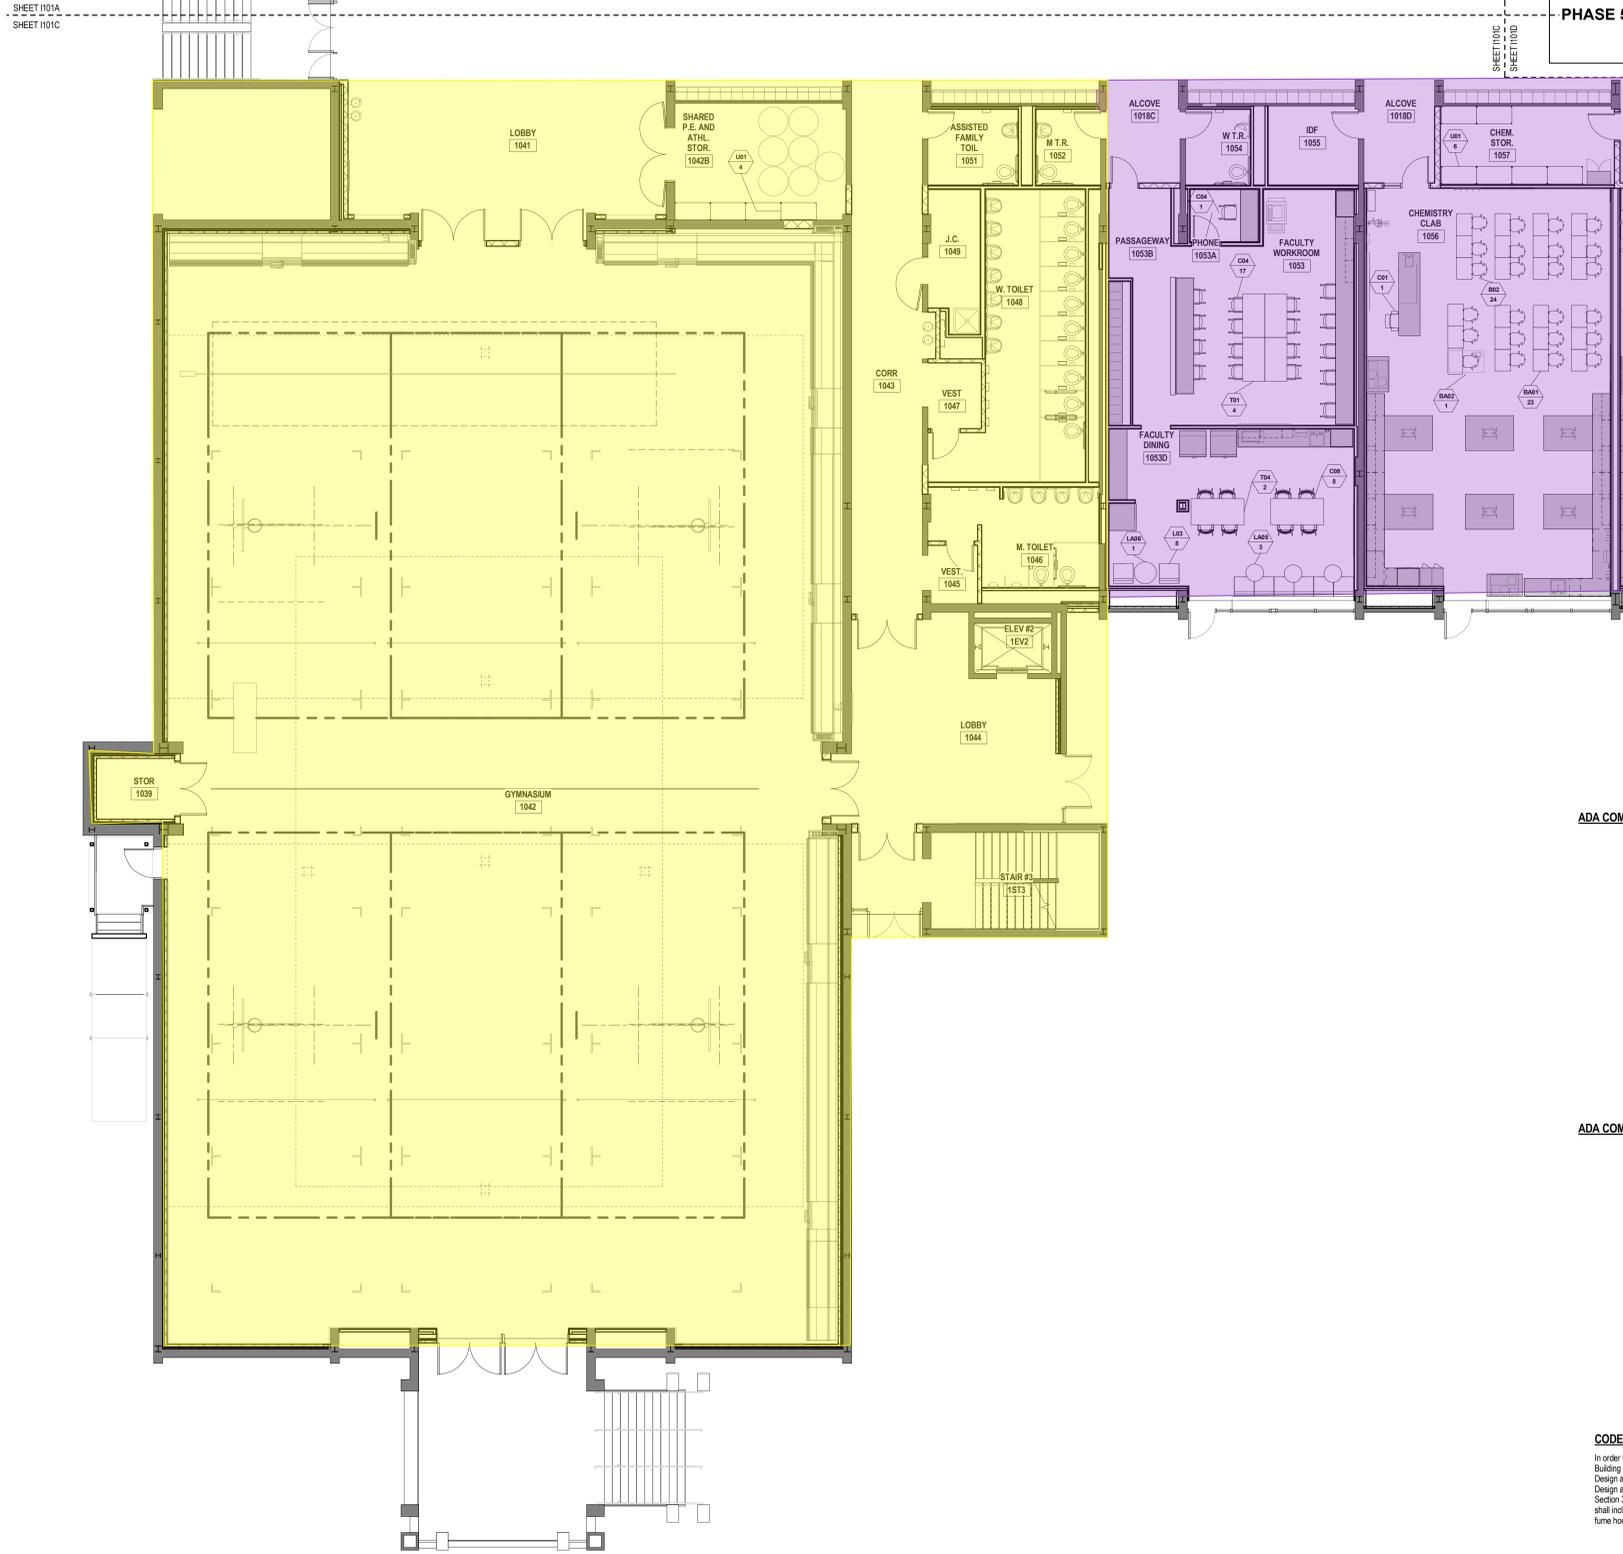

FF&E PHASING SCHEDULE

PHASE 1; TO BE DELIVERED AUGUST 2018	
PHASE 2; TO BE DELIVERED DECEMBER 2018	
PHASE 3; TO BE DELIVERED APRIL 2019	
PHASE 4; TO BE DELIVERED AUGUST 2019	
PHASE 5; TO BE DELIVERED NOVEMBER 2019	

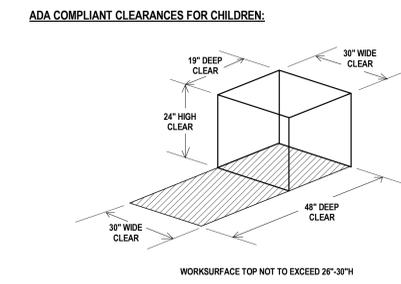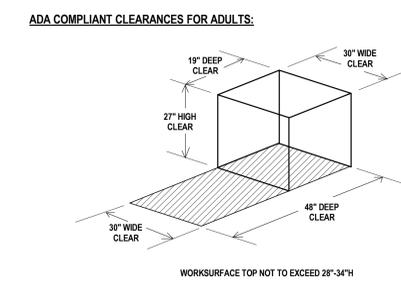

CODE COMPLIANCE NOTE:
 In order to meet the needs of persons with disabilities, when applicable all items shall comply with the current Connecticut Basic Building Code including 2003 ICC/ANSI A117.1, Section 504 Rehabilitation Act 1973, including the 2010 ADA Standards for Accessible Design and Section 504 Regulations, and the Americans with Disabilities Act Title II, including the 2010 ADA Standards for Accessible Design and ADA Regulations. Accessible area and toe clearances shall comply with 2010 ADA Standards for Accessible Design, Section 308. Compliance with the current Connecticut Fire Safety Code and current O.S.H.A. Title 29 Labor is also required. The items shall include, but are not limited to, fixtures, furnishings, equipment, workstations (including built-ins), playground equipment, laboratory fume hoods, deskroom equipment, welding stations, shop equipment and etc. Secure Attachment of FF&E items

SECURE ATTACHMENT NOTE:
 To ensure proper attachment of Fixtures, Furnishings & Equipment items, including Technology items, where "Items" are attached to wall, ceiling, and/or floor, Contractor shall provide information adequate to verify that fixtures, furnishings and equipment attached to wall, ceiling and/or floor are attached securely. Architect's review may be implemented during submittal process.
 Contractor shall provide struts, hangers, fasteners, safety harnesses, channels, bolts, screws, rods, and etc. to securely attach items to existing structure as required to meet field conditions and meet applicable code.

*REFER TO FURNITURE SCHEDULE BY ROOM ON SHEET I200 FOR COMPLETE LIST OF ALL FF&E ITEMS IN ALL ROOMS

ITEMS SHOWN SHADED ARE PART OF THE CONSTRUCTION PACKAGE (INCLUDING MILLWORK, CASEWORK AND EQUIPMENT) AND ARE FOR REFERENCE ONLY.


SLAM
 The S/I/L/A/M Collaborative
 80 Glastonbury Blvd
 Glastonbury, CT 06033-4410
 phone 860 657.8077
 fax 860 657.3141
 www.slamcoll.com

Drawn	AH
Checked	
Checker	



NONNEWAUG HIGH SCHOOL
 PHASE 3 of 3
 FIXTURES, FURNISHINGS & EQUIPMENT
 5 MINORTOWN RD
 WOODBURY, CT 06798

STATE PROJECT NO. 214-0093 RN
 STATE PROJECT NO. 214-0096 BE/A/CV

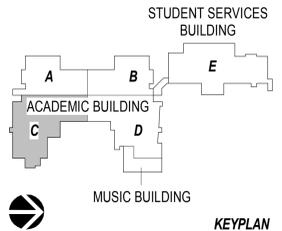

Number	Date	Issued For
11/15/2017		ISSUED FOR BID

FIRST FLOOR FURNITURE PLAN - PART C INSTALLATION PHASING

Date	01-12-2018	Drawing Number	I101C
Scale	As indicated	Proj. Number	15232.00

1 FIRST FLOOR FURNITURE PLAN - PART C
 1/8" = 1'-0"

© 2017 The SLAM Collaborative, Inc. C:\Revit\Projects\Nonnewaug_A_S\I101C_2018_12\15232.00.dwg 4/2/2018 10:24:42 AM

1

2

3

4

5

A

B


C

D


E

FF&E PHASING SCHEDULE


PHASE 1; TO BE DELIVERED AUGUST 2018	
PHASE 2; TO BE DELIVERED DECEMBER 2018	
PHASE 3; TO BE DELIVERED APRIL 2019	
PHASE 4; TO BE DELIVERED AUGUST 2019	
PHASE 5; TO BE DELIVERED NOVEMBER 2019	

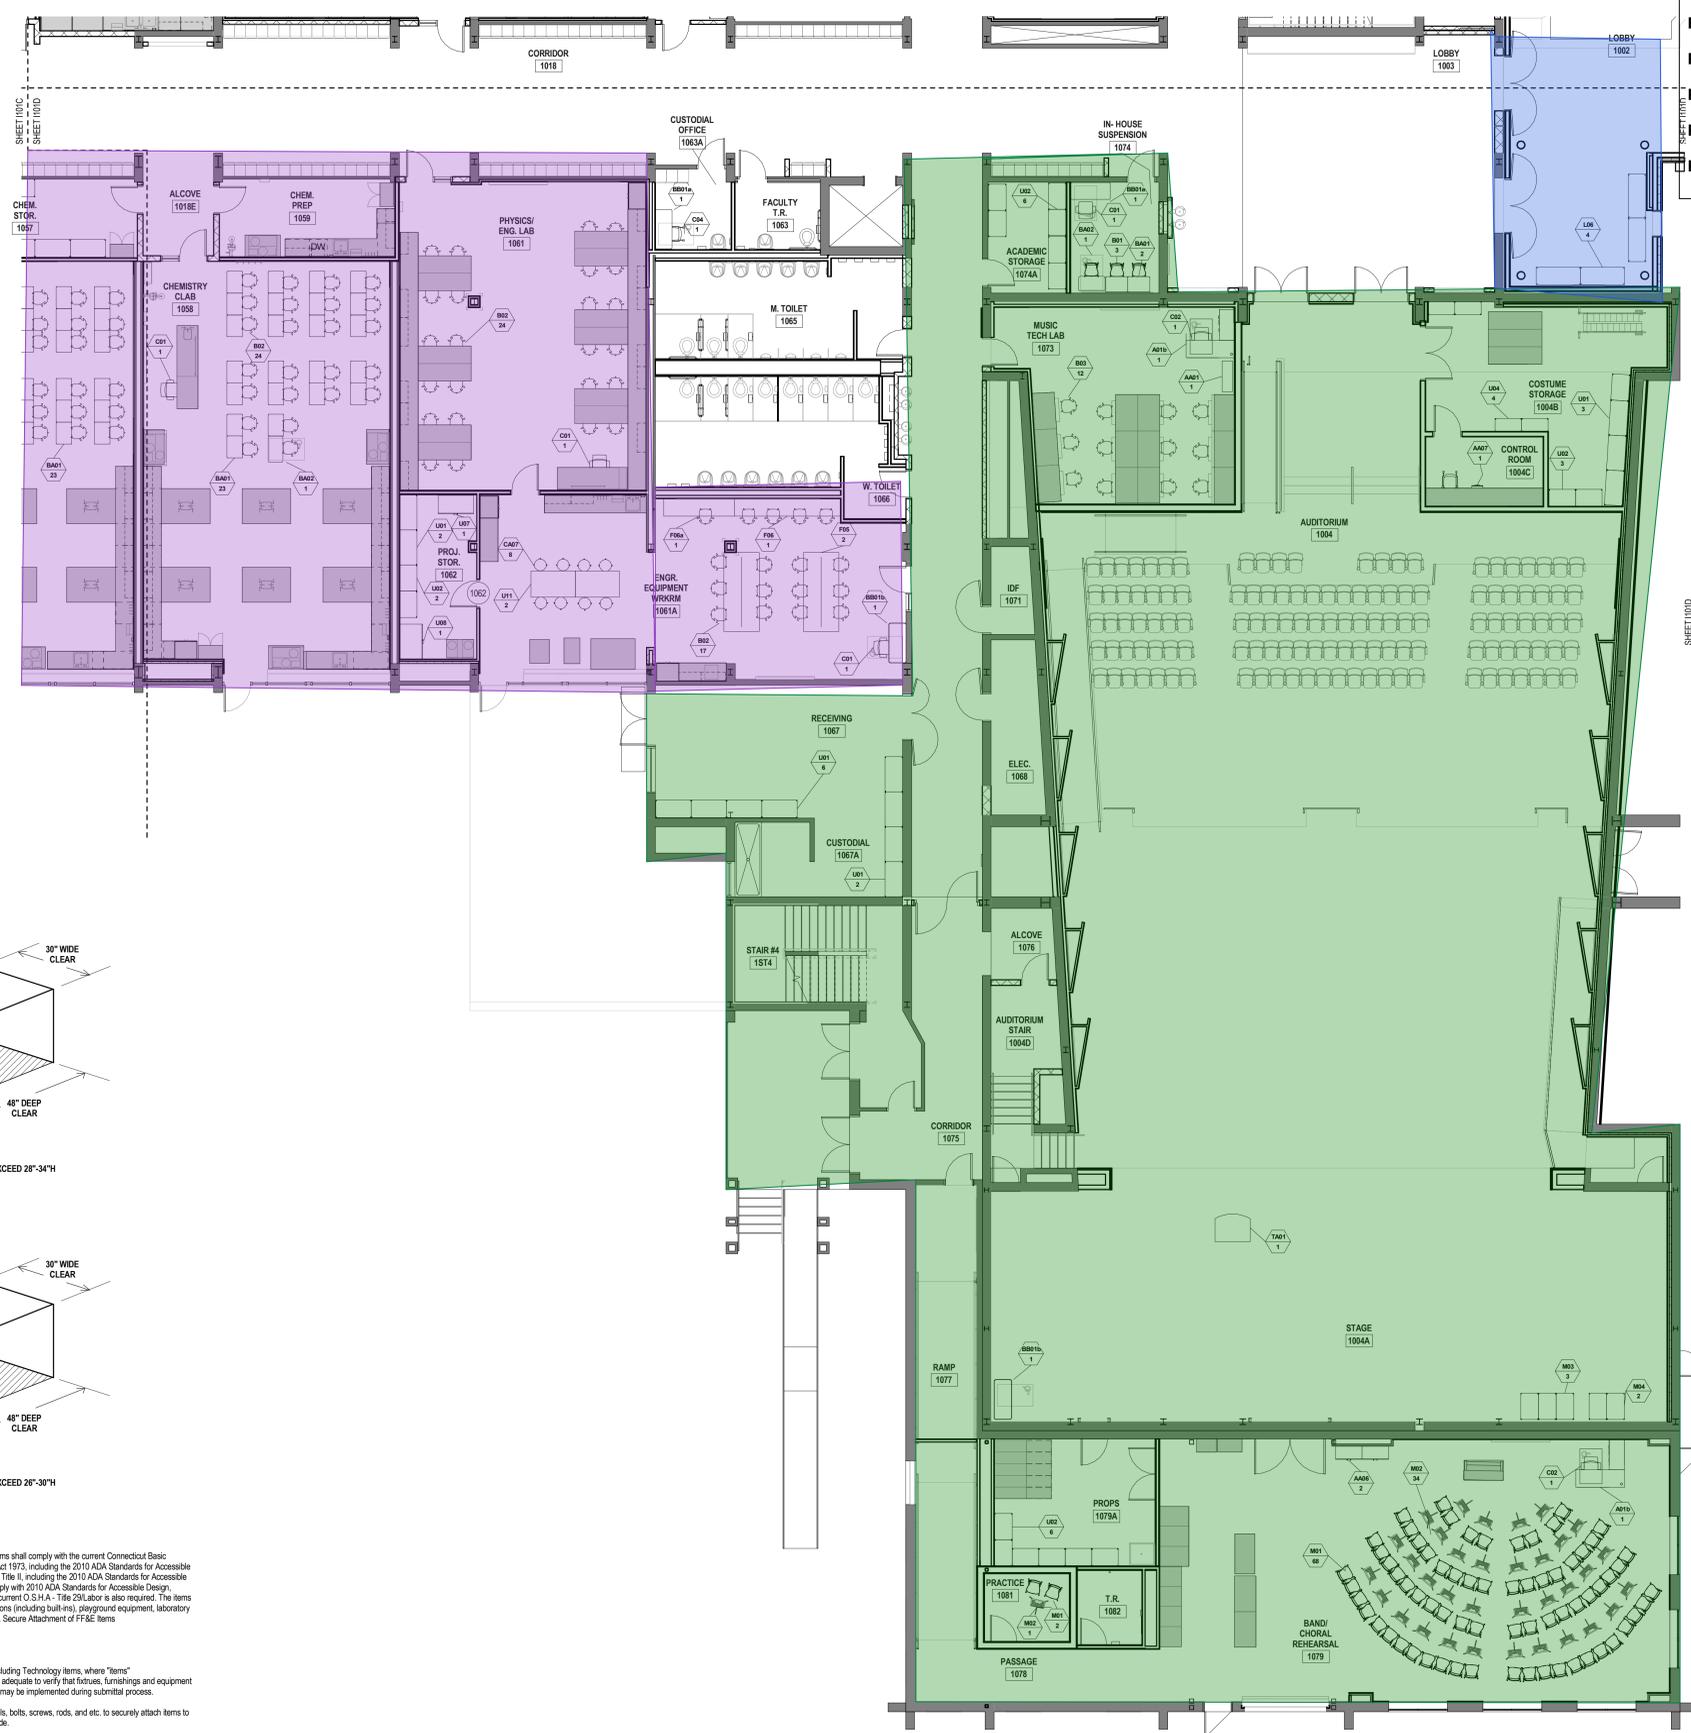

ADA COMPLIANT CLEARANCES FOR ADULTS:

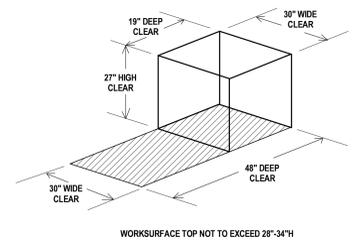

ADA COMPLIANT CLEARANCES FOR CHILDREN:

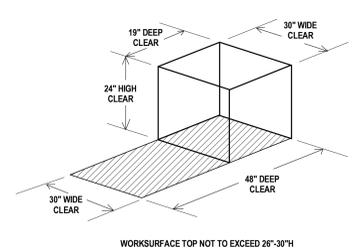

CODE COMPLIANCE NOTE:

In order to meet the needs of persons with disabilities, when applicable all items shall comply with the current Connecticut Basic Building Code including 2003 ICC/ANSI A117.1, Section 504 Rehabilitation Act 1973, including the 2010 ADA Standards for Accessible Design and Section 504 Regulations, and the Americans with Disabilities Act Title II, including the 2010 ADA Standards for Accessible Design and ADA Regulations. Accessible knee and toe clearances shall comply with 2010 ADA Standards for Accessible Design. Section 306. Compliance with the current Connecticut Fire Safety Code and current O.S.H.A. Title 29 Labor is also required. The items shall include, but are not limited to, fixtures, furnishings, equipment, workstations (including built-ins), playground equipment, laboratory fume hoods, darkroom equipment, welding stations, shop equipment and etc. Secure Attachment of FF&E Items

SECURE ATTACHMENT NOTE:

To ensure proper attachment of Fixtures, Furnishings & Equipment items, including Technology items, where "Items" are attached to wall, ceiling, and/or floor, Contractor shall provide information adequate to verify that fixtures, furnishings and equipment attached to wall, ceiling and/or floor are attached securely. Architects review may be implemented during submittal process. Contractor shall provide struts, hangers, fasteners, safety harnesses, channels, bolts, screws, rods, and etc. to securely attach items to existing structure as required to meet field conditions and meet applicable code.

*REFER TO FURNITURE SCHEDULE BY ROOM ON SHEET I200 FOR COMPLETE LIST OF ALL FF&E ITEMS IN ALL ROOMS

ITEMS SHOWN SHADED ARE PART OF THE CONSTRUCTION PACKAGE (INCLUDING MILLWORK, CASEWORK AND EQUIPMENT) AND ARE FOR REFERENCE ONLY.

1 FIRST FLOOR FURNITURE PLAN - PART D
1/8" = 1'-0"

SLAM
The S/L/A/M Collaborative

80 Glastonbury Blvd
Glastonbury, CT 06033-4410
phone 860.657.8077
fax 860.657.3141

www.slamcoll.com


Drawn
AH
Checked
Checker

Region 14 Schools
Inspiring Excellence

NONNEWAUG HIGH SCHOOL
PHASE 3 of 3
FIXTURES, FURNISHINGS & EQUIPMENT

5 MINORTOWN RD
WOODBURY, CT 06798

STATE PROJECT NO. 214-0093 RN
STATE PROJECT NO. 214-0096 BE/A/CV

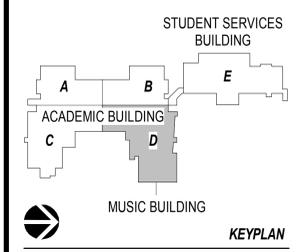

Number	Date	Issued For
1	11/15/2017	ISSUED FOR BID

FIRST FLOOR FURNITURE PLAN - PART D
INSTALLATION PHASING

Date: 01-12-2018
Scale: As indicated
Proj. Number: 15232.00
Drawing Number: **I101D**

© 2017 The SLAM Collaborative, Inc. C:\Revit\Projects\Nonnewaug_A_SLAM_122016_Hastings@slamcoll.com.rvt 4/2/2018 10:26:03 AM

FF&E PHASING SCHEDULE	
PHASE 1; TO BE DELIVERED AUGUST 2018	
PHASE 2; TO BE DELIVERED DECEMBER 2018	
PHASE 3; TO BE DELIVERED APRIL 2019	
PHASE 4; TO BE DELIVERED AUGUST 2019	
PHASE 5; TO BE DELIVERED NOVEMBER 2019	

SLAM
The S/L/A/M Collaborative

80 Glastonbury Blvd
Glastonbury, CT 06033-4410
phone 860 657.8077
fax 860 657.3141
www.slamcoll.com


Drawn
AH

Checked
Checker



NONNEWAUG HIGH SCHOOL
PHASE 3 of 3
FIXTURES, FURNISHINGS & EQUIPMENT
5 MINORTOWN RD
WOODBURY, CT 06798

STATE PROJECT NO. 214-0093 RN
STATE PROJECT NO. 214-0096 BE/A/CV

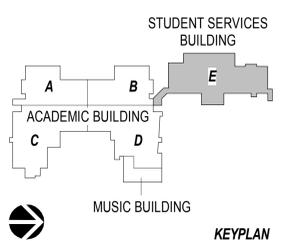

Number	Date	Issued For
11/15/2017	ISSUED FOR BID	


**FIRST FLOOR FURNITURE PLAN - PART E
INSTALLATION PHASING**

Date: 01-12-2018
Drawing Number: **1101E**
Scale: As indicated
Proj. Number: 15232.00




1 FIRST FLOOR FURNITURE PLAN - PART E
1/8" = 1'-0"

ADA COMPLIANT CLEARANCES FOR ADULTS:

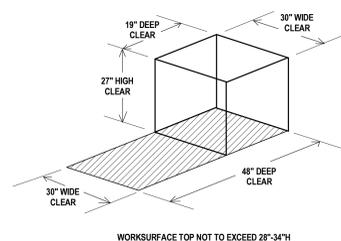

ADA COMPLIANT CLEARANCES FOR CHILDREN:

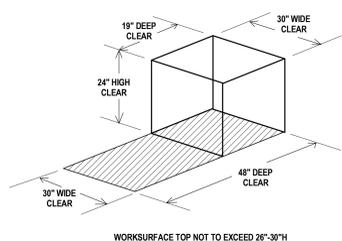

CODE COMPLIANCE NOTE:
In order to meet the needs of persons with disabilities, when applicable all items shall comply with the current Connecticut Basic Building Code including 2003 ICC(ANSI) A117.1, Section 504 Rehabilitation Act 1973, including the 2010 ADA Standards for Accessible Design and Section 504 Regulations, and the Americans with Disabilities Act Title II, including the 2010 ADA Standards for Accessible Design and ADA Regulations. Accessible knee and toe clearances shall comply with 2010 ADA Standards for Accessible Design, Section 505. Compliance with the current Connecticut Fire Safety Code and current O.S.H.A. - Title 29 Labor is also required. The items shall include, but are not limited to, fixtures, furnishings, equipment, workstations (including built-ins), playground equipment, laboratory fume hoods, darkroom equipment, welding stations, shop equipment and etc. Secure Attachment of FF&E items.

SECURE ATTACHMENT NOTE:
To ensure proper attachment of Fixtures, Furnishings & Equipment items, including Technology items, where "Items" are attached to wall, ceiling and/or floor, Contractor shall provide information adequate to verify that fixtures, furnishings and equipment attached to wall, ceiling and/or floor are attached securely. Architect's review may be implemented during submittal process.

Contractor shall provide struts, hangers, fasteners, safety harnesses, channels, bolts, screws, rods, and etc. to securely attach items to existing structure as required to meet field conditions and meet applicable code.

*REFER TO FURNITURE SCHEDULE BY ROOM ON SHEET 1200 FOR COMPLETE LIST OF ALL FF&E ITEMS IN ALL ROOMS
ITEMS SHOWN SHADED ARE PART OF THE CONSTRUCTION PACKAGE (INCLUDING MILLWORK, CASEWORK, AND EQUIPMENT) AND ARE FOR REFERENCE ONLY.

© 2017 The SLAM Collaborative, Inc. C:\Revit\Projects\Nonnewaug_A_SLAM_202016_Hastings@slamcoll.com.rvt 4/2/2018 10:26:16 AM

Drawn AH	
Checked Checker	

FF&E PHASING SCHEDULE	
PHASE 1; TO BE DELIVERED AUGUST 2018	
PHASE 2; TO BE DELIVERED DECEMBER 2018	
PHASE 3; TO BE DELIVERED APRIL 2019	
PHASE 4; TO BE DELIVERED AUGUST 2019	
PHASE 5; TO BE DELIVERED NOVEMBER 2019	



1 SECOND FLOOR FURNITURE PLAN - PART A
1/8" = 1'-0"




NONNEWAUG HIGH SCHOOL

PHASE 3 of 3
FIXTURES, FURNISHINGS & EQUIPMENT

5 MINORTOWN RD
WOODBURY, CT 06798

STATE PROJECT NO. 214-0093 RN
STATE PROJECT NO. 214-0096 BE/A/CV

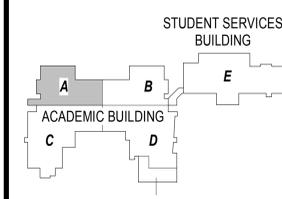


KEYPLAN

Number	Date	Issued For


SECOND FLOOR FURNITURE PLAN - PART A INSTALLATION PHASING

Date	01-12-2018	Drawing Number	1102A
Scale	As indicated	Proj. Number	15232.00

ADA COMPLIANT CLEARANCES FOR ADULTS:

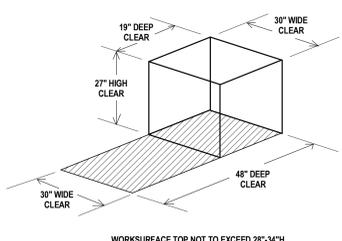

ADA COMPLIANT CLEARANCES FOR CHILDREN:

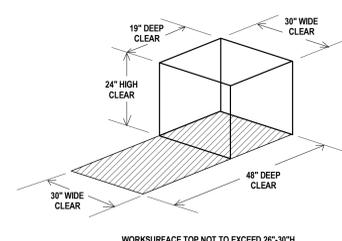

CODE COMPLIANCE NOTE:

In order to meet the needs of persons with disabilities, when applicable all items shall comply with the current Connecticut Basic Building Code including 2003 ICC/ANSI A117.1, Section 504 Rehabilitation Act 1973, including the 2010 ADA Standards for Accessible Design and Section 504 Regulations, and the Americans with Disabilities Act Title II, including the 2010 ADA Standards for Accessible Design and ADA Regulations. Accessible knee and toe clearances shall comply with 2010 ADA Standards for Accessible Design, Section 308. Compliance with the current Connecticut Fire Safety Code and current O.S.H.A. - Title 29 Labor is also required. The items shall include, but are not limited to, fixtures, furnishings, equipment, workstations (including built-ins), playground equipment, laboratory fume hoods, denroom equipment, welding stations, shop equipment and etc. Secure Attachment of FF&E Items

SECURE ATTACHMENT NOTE:

To ensure proper attachment of Fixtures, Furnishings & Equipment items, including Technology items, where "Items" are attached to wall, ceiling, and/or floor, Contractor shall provide information adequate to verify that fixtures, furnishings and equipment attached to wall, ceiling and/or floor are attached securely. Architect's review may be implemented during submittal process.

Contractor shall provide struts, hangers, fasteners, safety harnesses, channels, bolts, screws, rods, and etc. to securely attach items to existing structure as required to meet field conditions and meet applicable code.

*REFER TO FURNITURE SCHEDULE BY ROOM ON SHEET I200 FOR COMPLETE LIST OF ALL FF&E ITEMS IN ALL ROOMS. ITEMS SHOWN SHADED ARE PART OF THE CONSTRUCTION PACKAGE (INCLUDING MILLWORK, CASEWORK, AND EQUIPMENT) AND ARE FOR REFERENCE ONLY.

C:\Revit\Projects\Nonnewaug_A_SLAM_02016_Hastings@slamcoll.com.rvt 4/2/2018 10:27:00 AM

Drawn	AH
Checked	
Checker	

FF&E PHASING SCHEDULE

- PHASE 1; TO BE DELIVERED AUGUST 2018
- PHASE 2; TO BE DELIVERED DECEMBER 2018
- PHASE 3; TO BE DELIVERED APRIL 2019
- PHASE 4; TO BE DELIVERED AUGUST 2019
- PHASE 5; TO BE DELIVERED NOVEMBER 2019



1 SECOND FLOOR FURNITURE PLAN - PART B
1/8" = 1'-0"




NONNEWAUG HIGH SCHOOL

PHASE 3 of 3
FIXTURES, FURNISHINGS & EQUIPMENT

5 MINORTOWN RD
WOODBURY, CT 06798


STATE PROJECT NO. 214-0093 RN
STATE PROJECT NO. 214-0096 BE/A/CV

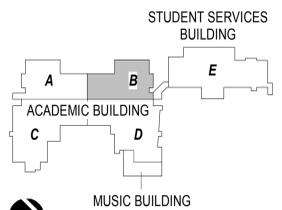


KEYPLAN

Number	Date	Issued For

ADA COMPLIANT CLEARANCES FOR ADULTS:

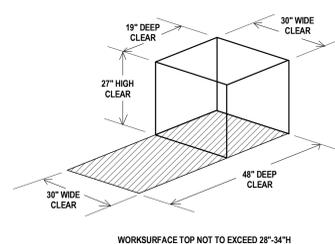

ADA COMPLIANT CLEARANCES FOR CHILDREN:

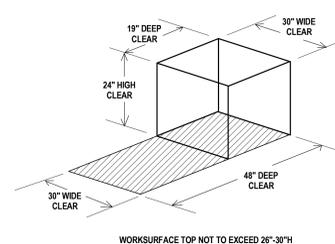

CODE COMPLIANCE NOTE:

In order to meet the needs of persons with disabilities, when applicable all items shall comply with the current Connecticut Basic Building Code including 2003 ICC/ANSI A117.1, Section 044 Rehabilitation Act 1973, including the 2010 ADA Standards for Accessible Design and Section 504 Regulations, and the Americans with Disabilities Act Title II, including the 2010 ADA Standards for Accessible Design and ADA Regulations. Accessible knee and toe clearances shall comply with 2010 ADA Standards for Accessible Design, Section 306. Compliance with the current Connecticut Fire Safety Code and current O.S.H.A. - Title 29 Labor is also required. The items shall include, but are not limited to, fixtures, furnishings, equipment, workstations (including built-ins), playground equipment, laboratory fume hoods, classroom equipment, welding stations, shop equipment and etc. Secure Attachment of FF&E Items

SECURE ATTACHMENT NOTE:

To ensure proper attachment of Fixtures, Furnishings & Equipment items, including Technology items, where "Items" are attached to wall, ceiling, and/or floor. Contractor shall provide information adequate to verify that fixtures, furnishings and equipment attached to wall, ceiling and/or floor are attached securely. Architect's review may be implemented during submittal process.

Contractor shall provide struts, hangers, fasteners, safety harnesses, channels, bolts, screws, rods, and etc. to securely attach items to existing structure as required to meet field conditions and meet applicable code.

*REFER TO FURNITURE SCHEDULE BY ROOM ON SHEET I200 FOR COMPLETE LIST OF ALL FF&E ITEMS IN ALL ROOMS
ITEMS SHOWN SHADED ARE PART OF THE CONSTRUCTION PACKAGE (INCLUDING MILLWORK, CASEWORK, AND EQUIPMENT) AND ARE FOR REFERENCE ONLY.

SECOND FLOOR FURNITURE PLAN - PART B INSTALLATION PHASING

Date	01-12-2018	Drawing Number	I102B
Scale	As indicated	Proj. Number	15232.00

A

B

C



D

E



FF&E PHASING SCHEDULE

- PHASE 1; TO BE DELIVERED AUGUST 2018
- PHASE 2; TO BE DELIVERED DECEMBER 2018
- PHASE 3; TO BE DELIVERED APRIL 2019
- PHASE 4; TO BE DELIVERED AUGUST 2019
- PHASE 5; TO BE DELIVERED NOVEMBER 2019

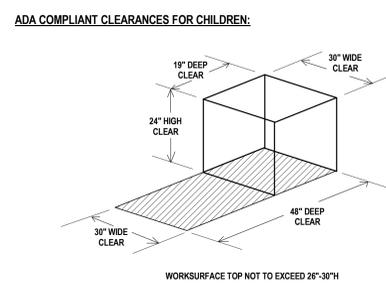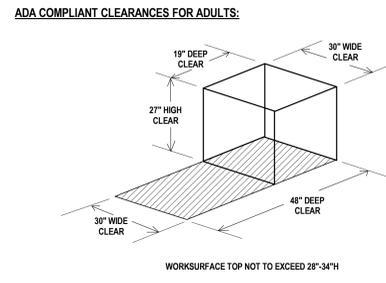

CODE COMPLIANCE NOTE:
 In order to meet the needs of persons with disabilities, when applicable all items shall comply with the current Connecticut Building Code including 2003 ICC/ANSI A117.1, Section 504 Rehabilitation Act 1973, including the 2010 ADA Standards for Accessible Design and Section 504 Regulations, and the Americans with Disabilities Act Title II, including the 2010 ADA Standards for Accessible Design and ADA Regulations. Accessible knee and toe clearances shall comply with 2010 ADA Standards for Accessible Design, Section 306. Compliance with the current Connecticut Fire Safety Code and current O.S.H.A. Title 29 Labor is also required. The items shall include, but are not limited to, fixtures, furnishings, equipment, workstations including built-ins, playground equipment, laboratory fume hoods, darkroom equipment, welding stations, shop equipment and etc. Secure Attachment of FF&E items

SECURE ATTACHMENT NOTE:
 To ensure proper attachment of fixtures, furnishings & Equipment items, including Technology items, where "items" are attached to wall, ceiling, and/or floor. Contractor shall provide information adequate to verify that fixtures, furnishings and equipment attached to wall, ceiling and/or floor are attached securely. Architect's review may be implemented during submittal process.
 Contractor shall provide struts, hangers, fasteners, safety harnesses, channels, bolts, screws, rods, and etc. to securely attach items to existing structure as required to meet field conditions and meet applicable code.

*REFER TO FURNITURE SCHEDULE BY ROOM ON SHEET I200 FOR COMPLETE LIST OF ALL FF&E ITEMS IN ALL ROOMS

ITEMS SHOWN SHADED ARE PART OF THE CONSTRUCTION PACKAGE (INCLUDING MILLWORK, CASEWORK AND EQUIPMENT) AND ARE FOR REFERENCE ONLY.

1 SECOND FLOOR PLAN
 1/8" = 1'-0"


Drawn
AH
 Checked
 Checker



NONNEWAUG HIGH SCHOOL
 PHASE 3 of 3
 FIXTURES, FURNISHINGS & EQUIPMENT

5 MINORTOWN RD
 WOODBURY, CT 06798

STATE PROJECT NO. 214-0093 RN
 STATE PROJECT NO. 214-0096 BE/A/CV

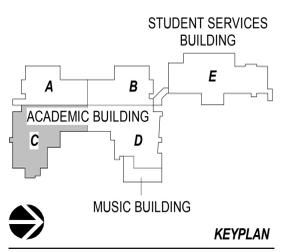

Number	Date	Issued For

SECOND FLOOR FURNITURE PLAN - PART C INSTALLATION PHASING

Date: 01-12-2018
 Scale: As indicated
 Proj. Number: 15232.00
 Drawing Number: **I102C**

1

2

3

4

5

A

B

C

D


E




FF&E PHASING SCHEDULE

PHASE 1; TO BE DELIVERED AUGUST 2018	
PHASE 2; TO BE DELIVERED DECEMBER 2018	
PHASE 3; TO BE DELIVERED APRIL 2019	
PHASE 4; TO BE DELIVERED AUGUST 2019	
PHASE 5; TO BE DELIVERED NOVEMBER 2019	

ADA COMPLIANT CLEARANCES FOR ADULTS:

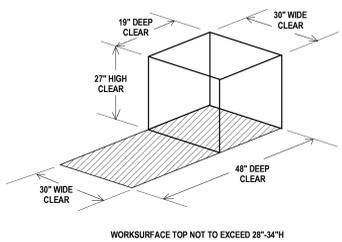

ADA COMPLIANT CLEARANCES FOR CHILDREN:

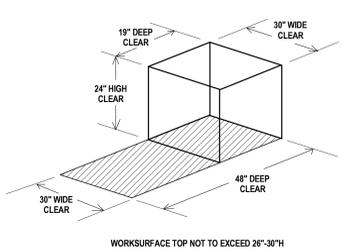

CODE COMPLIANCE NOTE:

In order to meet the needs of persons with disabilities, when applicable all items shall comply with the current Connecticut Basic Building Code including 2003 (C.G.S.) § 11-71, Section 504 Rehabilitation Act 1973, including the 2010 ADA Standards for Accessible Design and Section 504 Regulations, and the Americans with Disabilities Act Title II, including the 2010 ADA Standards for Accessible Design and ADA Regulations. Accessible knee and toe clearances shall comply with 2010 ADA Standards for Accessible Design, Section 305. Compliance with the current Connecticut Fire Safety Code and current C.S.A. - Title 29B floor is also required. The items shall include, but are not limited to, fixtures, furnishings, equipment, workstations (including built-ins), playground equipment, laboratory fume hoods, darkroom equipment, welding stations, shop equipment and etc. Secure Attachment of FF&E Items

SECURE ATTACHMENT NOTE:

To ensure proper attachment of Fixtures, Furnishings & Equipment items, including Technology items, where "Items" are attached to wall, ceiling and/or floor. Contractor shall provide information adequate to verify that fixtures, furnishings and equipment attached to wall, ceiling and/or floor are attached securely. Architect's review may be implemented during submittal process.

Contractor shall provide struts, hangers, fasteners, safety harnesses, channels, bolts, screws, rods, and etc. to securely attach items to existing structure as required to meet field conditions and meet applicable code.

*REFER TO FURNITURE SCHEDULE BY ROOM ON SHEET I200 FOR COMPLETE LIST OF ALL FF&E ITEMS IN ALL ROOMS

ITEMS SHOWN SHADED ARE PART OF THE CONSTRUCTION PACKAGE (INCLUDING MILLWORK, CASEWORK AND EQUIPMENT) AND ARE FOR REFERENCE ONLY.

1 SECOND FLOOR FURNITURE PLAN - PART D
1/8" = 1'-0"




80 Glastonbury Blvd
Glastonbury, CT 06033-4410
phone 860 657.8077
fax 860 657.3141
www.slamcoll.com

Drawn	AH
Checked	
Checker	



NONNEWAUG HIGH SCHOOL
PHASE 3 of 3
FIXTURES, FURNISHINGS & EQUIPMENT
5 MINORTOWN RD
WOODBURY, CT 06798

STATE PROJECT NO. 214-0093 RN
STATE PROJECT NO. 214-0096 BE/A/CV

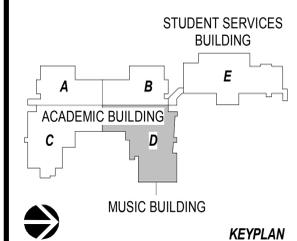

KEYPLAN

Number	Date	Issued For

SECOND FLOOR FURNITURE PLAN - PART D INSTALLATION PHASING

Date	01-12-2018	Drawing Number	I102D
Scale	As indicated	Proj. Number	15232.00

© 2018 The SLAM Collaborative, Inc. C:\Revit\Projects\Nonnewaug_A_SLAM_2018_Hastings@slamcoll.com.rvt 4/22/2018 10:28:25 AM