

ADDENDUM NO.: #7

DATE OF ADDENDUM: August 10, 2015

**Manufacturing Center Addition
Quinebaug Valley Community College
742 Upper Maple Street
Danielson, CT 06239
BI – CTC – 471**

Bid Due Date / Time:

August 12, 2015

1:00 pm

**Previous Addenda: Addendum #6 8/5/15, Addendum #5 7/28/15, Addendum #4 7/27/15,
Addendum #3 7/23/15, Addendum #2 7/8/15, Addendum #1 7/1/2015.**

TO: Prospective Bid Proposers:

This Addendum forms part of the "Contract Documents" and modifies or clarifies the original "Contract Documents" for this Project dated June 5, 2015. Prospective Bid Proposers shall acknowledge receipt of the total number the Addenda issued for this Project on the space provided on Section 00 41 00 Bid Proposal Form. Failure to do may subject Bid Proposers to disqualification.

The following clarifications are applicable to drawings and specifications for the project referenced above.


Item 1

The drawing issued (C-302) under item #5 in Addendum #6 was not readable.
The drawing is re-issued for clarification.

End of Addendum #7



**Mellanee Walton, Associate Fiscal Administrative Officer
Department of Administrative Services
On Behalf of the Division of Construction Services**

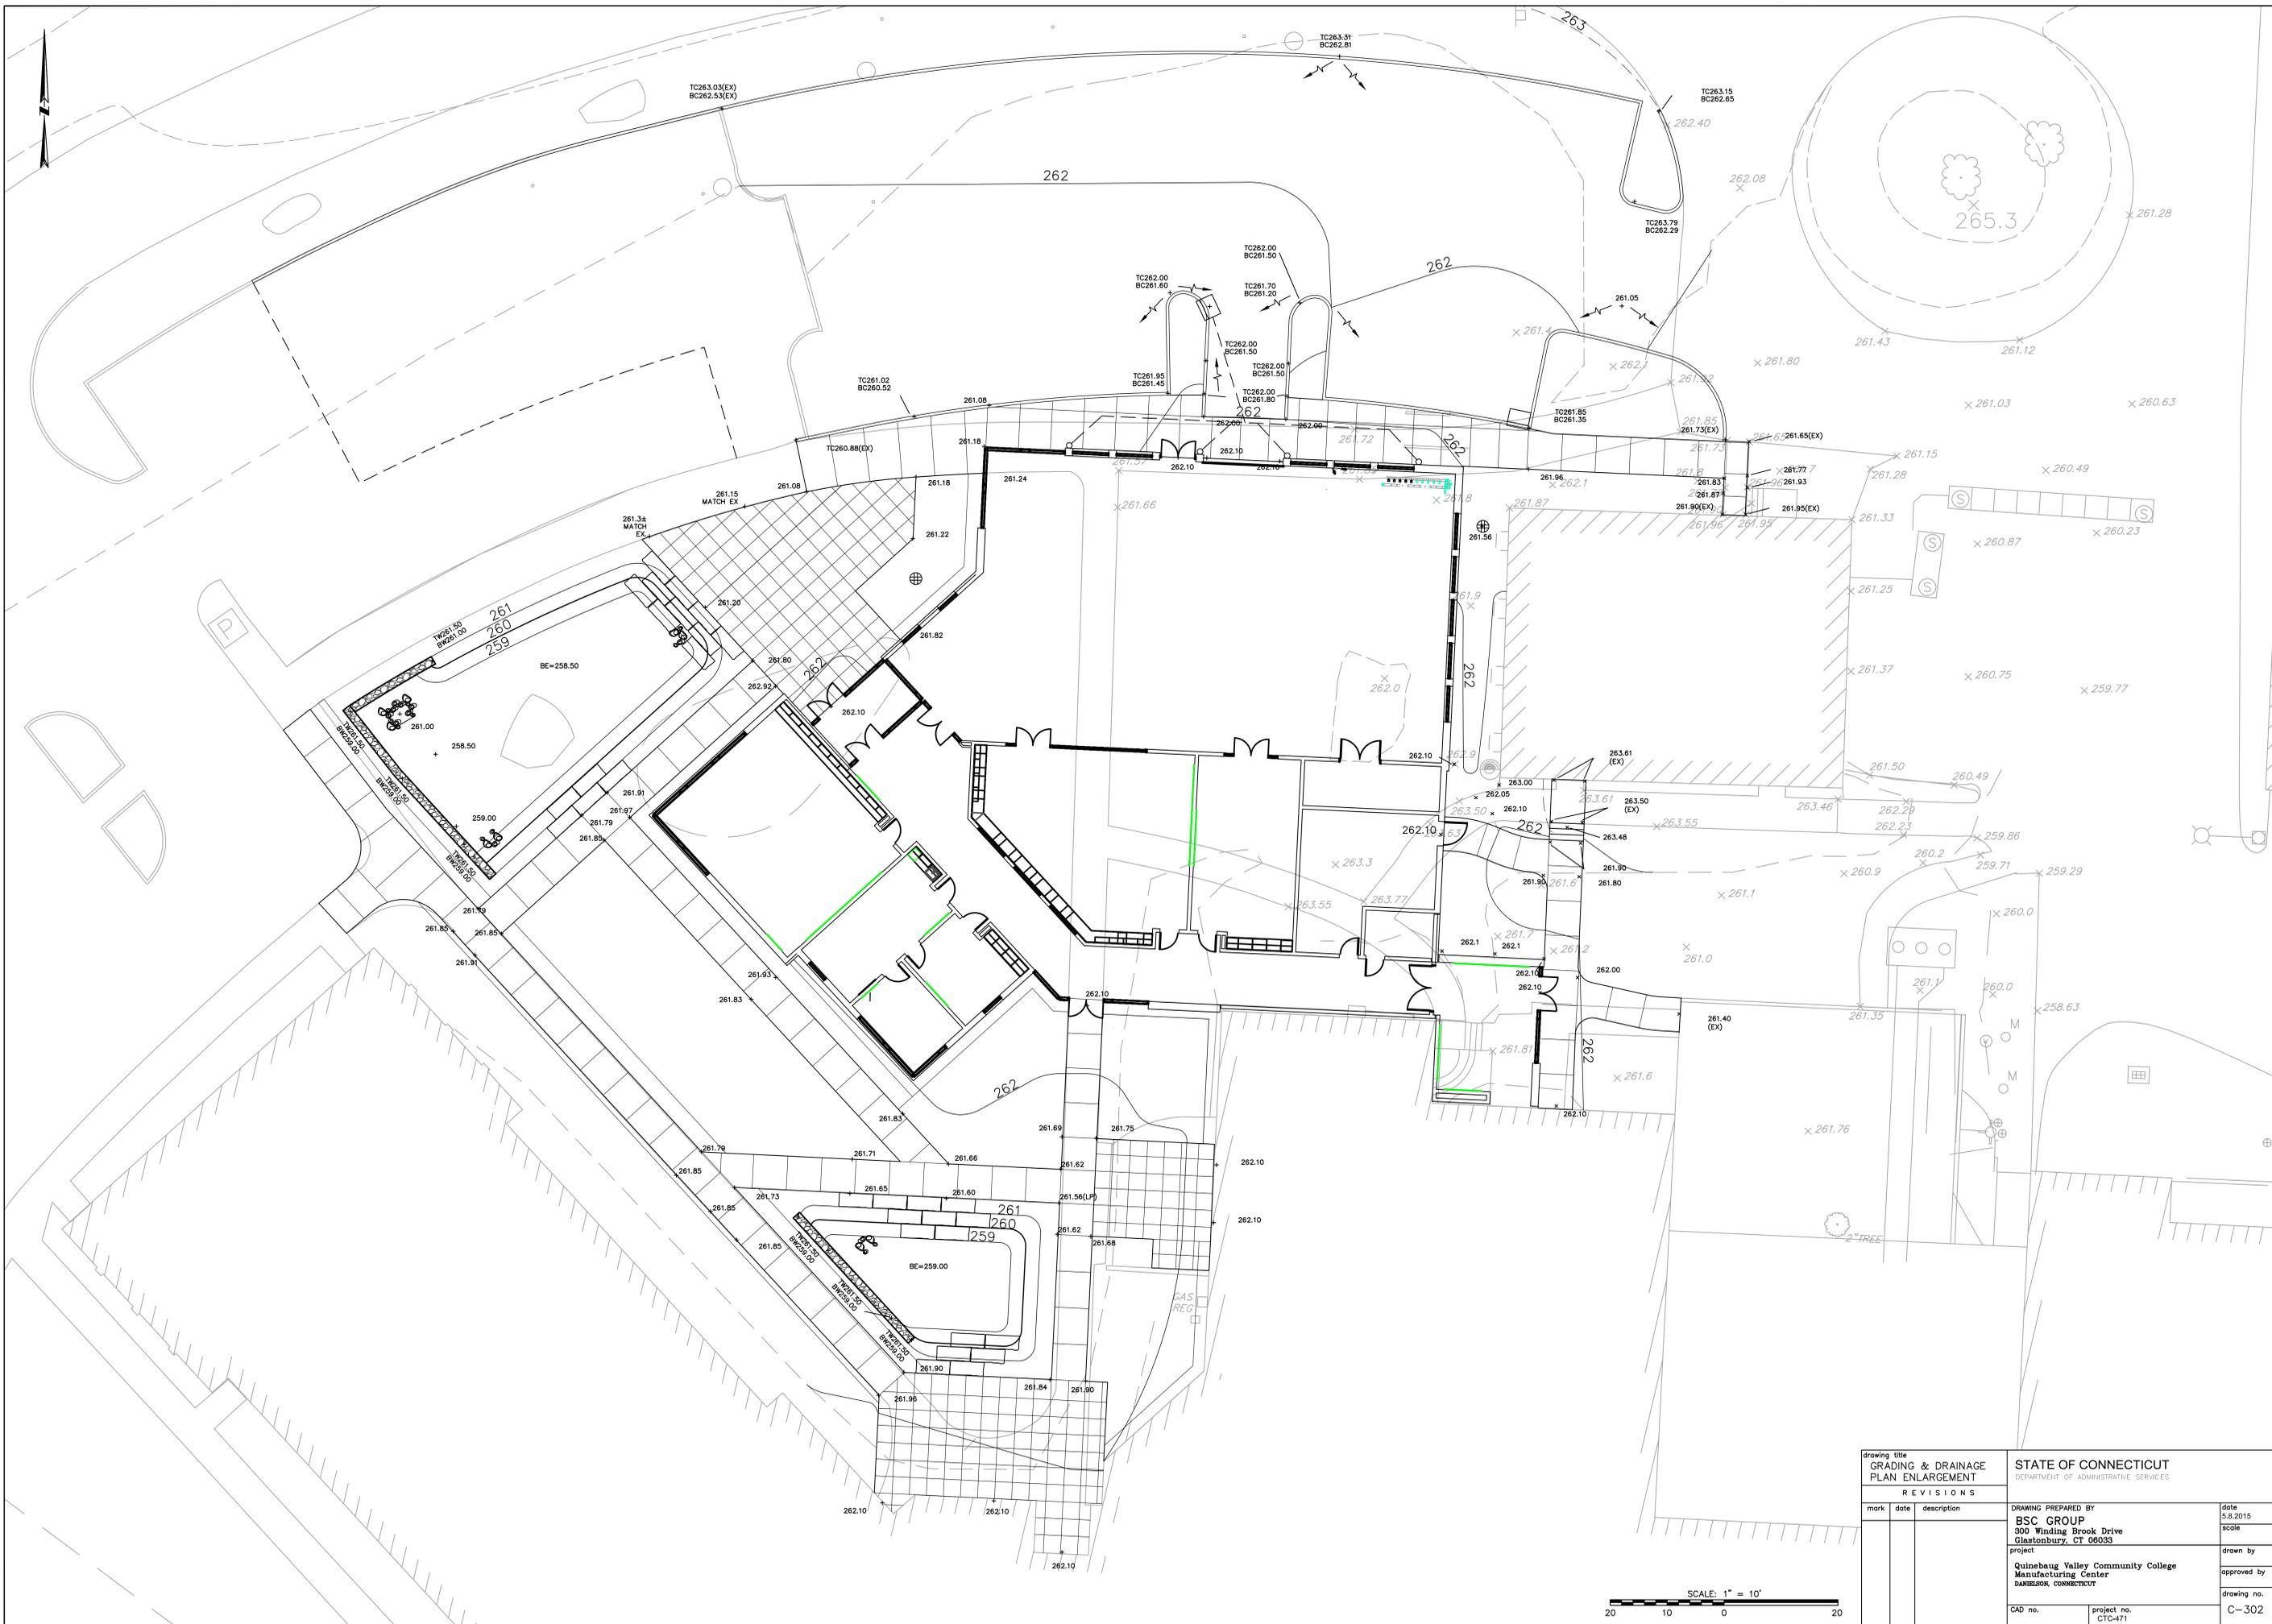

drawing title GRADING & DRAINAGE PLAN ENLARGEMENT		STATE OF CONNECTICUT DEPARTMENT OF ADMINISTRATIVE SERVICES	
REVISIONS			
mark	date	description	
DRAWING PREPARED BY BSC GROUP 300 Winding Brook Drive Glastonbury, CT 06033		date 5.8.2015	scale
project Quinebaug Valley Community College Manufacturing Center DANBROOK, CONNECTICUT		drawn by	approved by
CAD no.		project no. CTC-471	drawing no. C-302

